

觀塘區議會交通運輸委員會會議
運輸署 / 路政署過去兩個月內完成、正在施工或規劃中的主要交通改善工程項目及時間表


截至2026年3月13日

編號	項目編號	擬建的交通改善工程項目	地點	預期動工日期 [實際動工日期]	預期完工日期 [實際完工日期]	工程進度	詳細備註	運輸署工程師 姓名(電話)	路政署工程師 姓名(電話)
1	WR/25/00700	設立禁止學習駕駛時段	彩興路	25年12月 [26年02月]	26年01月 [26年02月]	0% 100%	懲教署會於2026年2月完成製作有關禁止學習駕駛時段路牌，路政署於接收路牌後會隨即安排施工。	李日新先生 甘浩熙先生 (2399 2513)	吳卓衡先生 (2707 7341)
2	WR/24/01562	行人輔助線髹上紅棕色警示	安茵街	25年11月 [26年01月]	[26年01月]	0% 100%	正進行有關工程的前期工作。工程已完成。	李日新先生 甘浩熙先生 (2399 2513)	吳卓衡先生 (2707 7341)
3	WR/25/00731	優化行人過路處(地下勘探工作)	曉明街近翠屏北邨翠楊樓	[25年09月]	26年02月 26年04月	50% 75%	正進行有關工程的前期工作。已開展工程，餘下地下勘探工作有待房委會工程完成後繼續。	陳展揚先生 (2399 2732)	葉沃增先生 (2707 7417)
4	WR/25/01253	加設行人輔助線	曉光街近曉光閣	[25年09月]	26年06月	0% 50%	正進行有關工程的前期工作。工程已開展。	陳展揚先生 (2399 2732)	葉沃增先生 (2707 7417)
5	WR/24/01576	加設路旁電單車泊車位	順清街	26年06月	27年06月	0%	正進行有關工程的前期工作。	李日新先生 甘浩熙先生 (2399 2513)	吳卓衡先生 (2707 7341)
6	WR/25/01251	拆除部分道路中央分隔欄及修改道路標記	油塘道近聖安當小學	26年05月	26年09月	0%	正進行有關工程的前期工作。	劉麗瑜女士 (2399 2502)	葉沃增先生 (2707 7417)
7	WR/25/01614	加設方向標誌	四山街	26年03月	26年08月	0%	正進行有關工程的前期工作。	劉麗瑜女士 (2399 2502)	葉沃增先生 (2707 7417)
8	WR/25/01661	加設行人提示標誌	安田街近藍田聖保祿中學	26年02月 26年05月	26年02月 26年05月	0%	正進行有關工程的前期工作。懲教署會於2026年5月完成製作有關路牌，路政署於接收路牌後會隨即安排施工。	劉麗瑜女士 (2399 2502)	葉沃增先生 (2707 7417)
9	WR/25/01588	加設路旁泊車位	茜發道近藍田港鐵站	26年02月 [26年01月]	26年03月 [26年02月]	20% 100%	已完成馬路中線改劃工程，電訊公司正安排餘下咪錶泊車位劃線及咪錶安裝工程。工程已完成。	羅淳哲先生 (2399 2459)	葉沃增先生 (2707 7417)
10	WR/25/00109	行人過路處改為按掣交通燈控制	利安道	26年06月	26年08月	0%	正進行有關工程的前期工作。	李日新先生 甘浩熙先生 (2399 2513)	吳卓衡先生 (2707 7341)
11	WR/25/01914	加設「巴士站」路面標記	仁宇圍	26年06月	26年08月	0%	正進行有關工程的前期工作。	劉麗瑜女士 (2399 2502)	葉沃增先生 (2707 7417)
12	WR/25/01802	加設專線小巴士站	崇信街近仁宇圍	26年05月	26年07月	0%	正進行有關工程的前期工作。	劉麗瑜女士 (2399 2502)	葉沃增先生 (2707 7417)

截至2026年3月13日


編號	項目編號	擬建的交通改善工程項目	地點	預期動工日期 [實際動工日期]	預期完工日期 [實際完工日期]	工程進度	詳細備註	運輸署工程師 姓名(電話)	路政署工程師 姓名(電話)
13	WR/25/01804	加設路旁電單車泊車位	崇和徑	26年08月	26年10月	0%	正進行有關工程的前期工作。	劉麗瑜 女士 (2399 2502)	葉沃增 先生 (2707 7417)
14	WR/25/01583	拆除部分路邊欄杆	寶琳路近觀音廟	[26年02月]	[26年02月]	100%	工程已完成。	陳展揚 先生 (2399 2732)	葉沃增 先生 (2707 7417)
15	WR/25/00893	加設道路中央分隔欄及交通分隔島	牛頭角道近牛頭角港 鐵站	[25年11月]	[26年01月]	100%	工程已完成。	黃進業 先生 (3842 6084)	葉沃增 先生 (2707 7417)
16	WR/26/00124	加設道路標記	安秀道安泰巴士總站	26年06月	26年07月	0%	正進行有關工程的前期工作。	甘浩熙 先生 (2399 2513)	吳卓衡 先生 (2707 7341)
17	WR/25/01902	加設路旁電單車泊車位 (地下勘探工作)	秀明道近秀茂坪邨秀 明樓	26年06月	26年08月	0%	正進行有關工程的前期工作。	陳展揚 先生 (2399 2732)	葉沃增 先生 (2707 7417)
18	WR/25/01904	加設路旁電單車泊車位 (地下勘探工作)	曉光街近曉麗苑曉和 閣	26年08月	26年10月	0%	正進行有關工程的前期工作。	陳展揚 先生 (2399 2732)	葉沃增 先生 (2707 7417)
19	WR/25/01718	加設「巴士站」路面標記	欣榮街近高宏苑	26年05月	26年07月	0%	正進行有關工程的前期工作。	劉麗瑜 女士 (2399 2502)	葉沃增 先生 (2707 7417)
20	WR/26/00077	增設交通標誌及道路標記	欣榮街	26年05月	26年07月	0%	正進行有關工程的前期工作。	劉麗瑜 女士 (2399 2502)	葉沃增 先生 (2707 7417)
21	WR/26/00243	調整道路標記	欣榮街近高超道	26年06月	26年07月	0%	正進行有關工程的前期工作。	劉麗瑜 女士 (2399 2502)	葉沃增 先生 (2707 7417)
22	WR/26/00067	調整道路標記	高超道近高超徑	26年07月	26年09月	0%	正進行有關工程的前期工作。	劉麗瑜 女士 (2399 2502)	葉沃增 先生 (2707 7417)
23	WR/26/00080	拆除小巴士站旁的部分行人欄杆	碧雲道近德隆樓	26年05月	26年06月	0%	正進行有關工程的前期工作。	劉麗瑜 女士 (2399 2502)	葉沃增 先生 (2707 7417)
24	WR/25/01252	加設「請勿停車」路面標記	恆安街近通明街	[26年02月]	[26年02月]	100%	工程已完成。	甘浩熙 先生 (2399 2513)	葉沃增 先生 (2707 7417)
25	WR/25/01192	加設傷殘人士泊車位	月華街近月華街遊樂 場	[26年02月]	[26年03月]	100%	工程已完成。	陳展揚 先生 (2399 2732)	葉沃增 先生 (2707 7417)
26	WR/25/01412	加設「的士上落客除外」標誌	偉業街近大業里	[26年02月]	[26年02月]	100%	工程已完成。	陳思豪 先生 (2399 2510)	吳卓衡 先生 (2707 7341)

備註: 更新的資料以紅字顯示

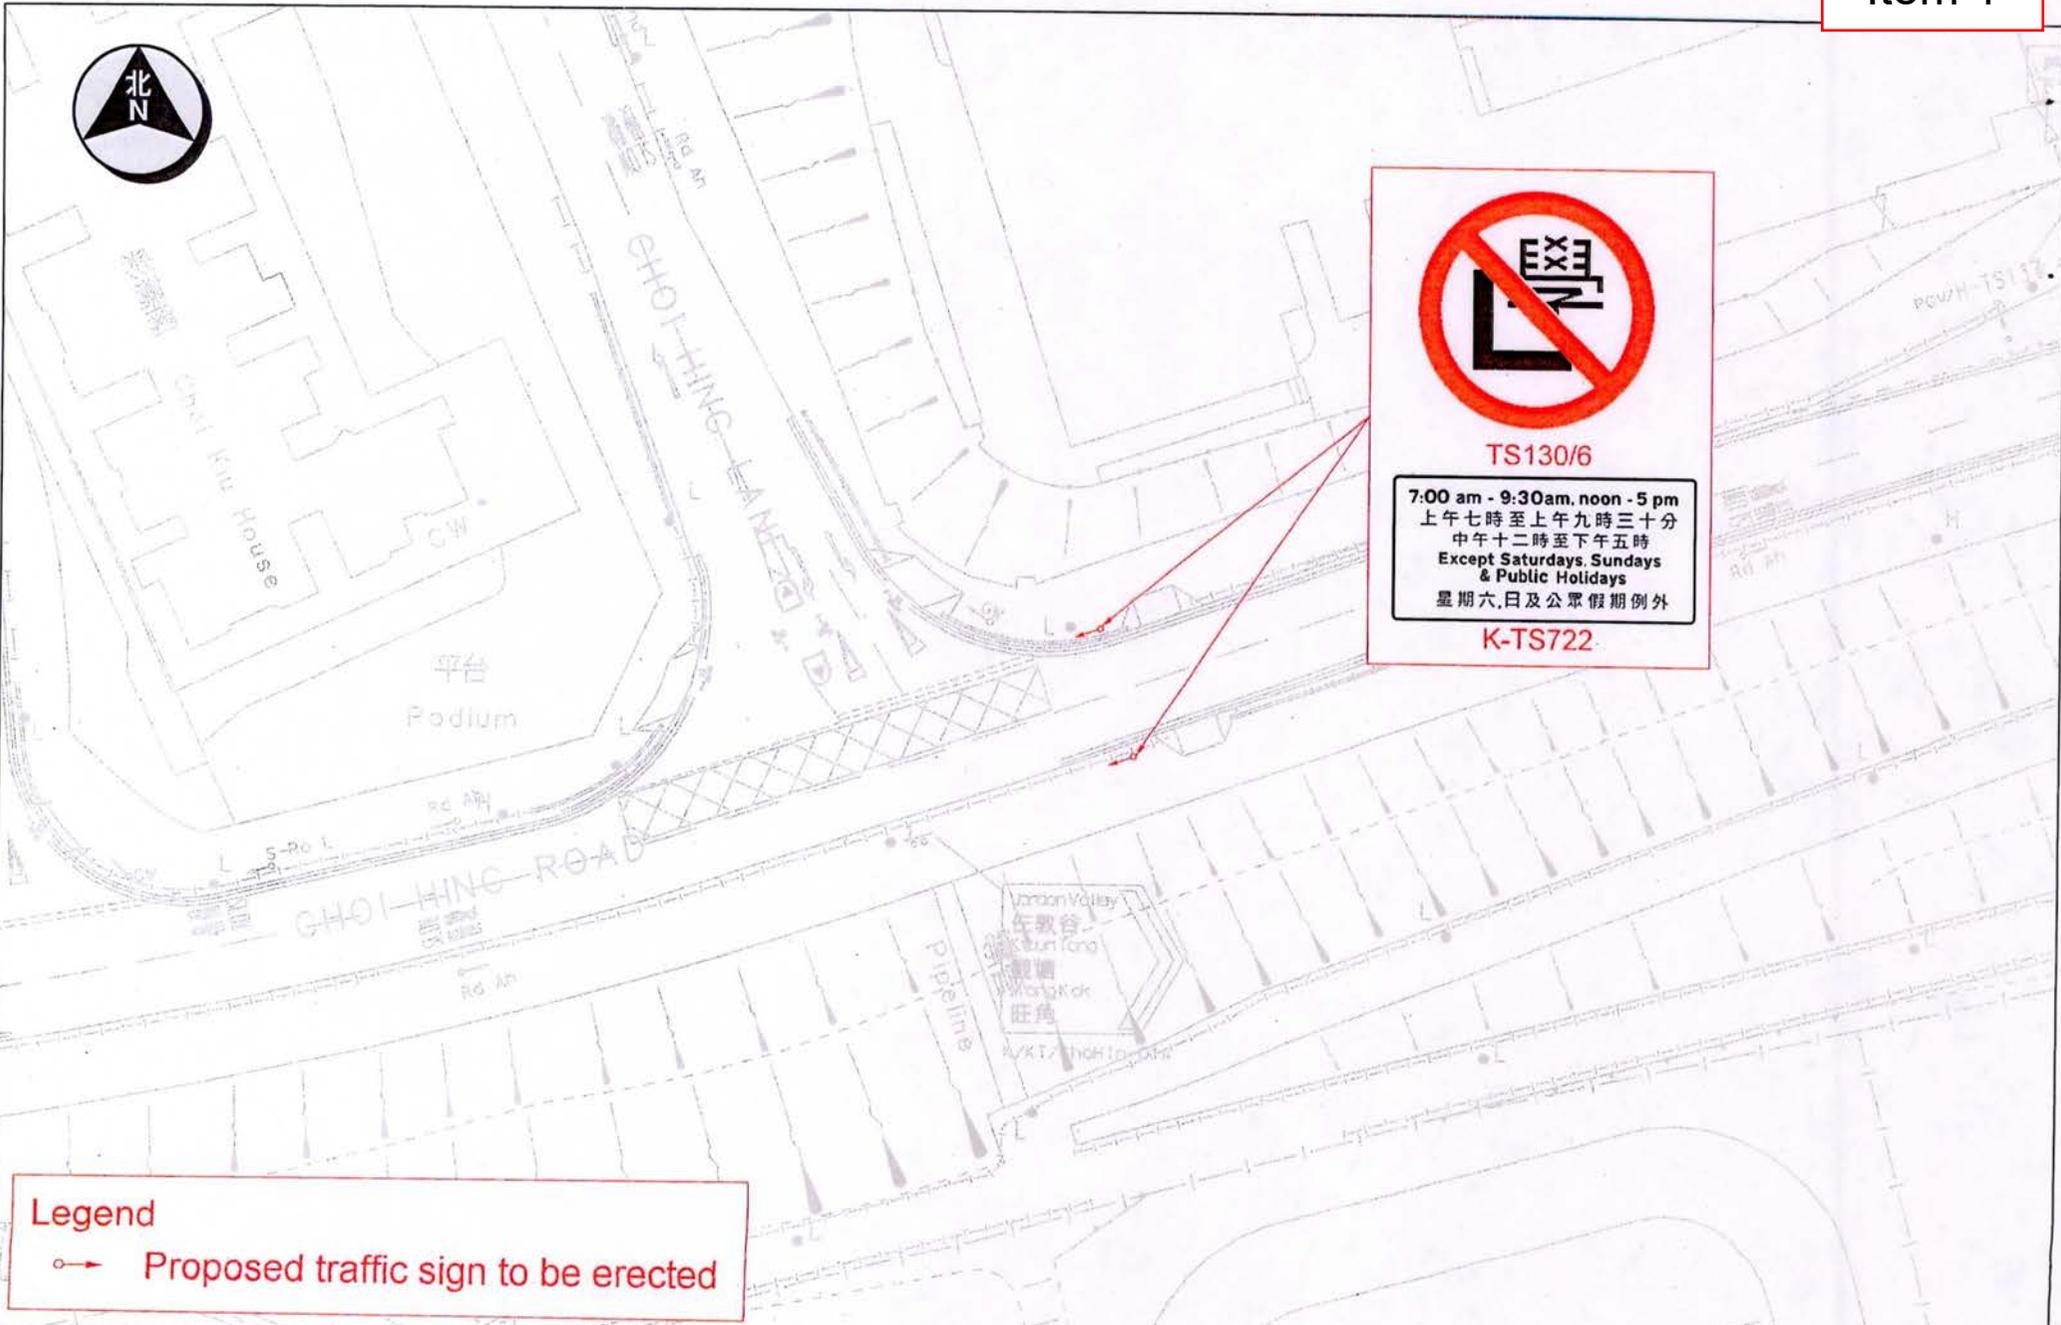

Legend
 → Proposed traffic sign to be erected

 <p>運輸署 Transport Department</p>	<p>TRAFFIC ENGINEERING (KLN.) DIV.</p>	<p>Location: Choi Hing Road near Choi Hing Lane Survey Sheet No. K11Q12B</p>	<p>Scale: 1:500 (A4)</p>	<p>Drawing No. K250176.01A</p>	<p>WRF NO. WR/HY/TE/KL/25/00700 WR/CS/TE/KL/25/00183 Date: 17 Mar 2025</p>
--	--	---	--------------------------	--------------------------------	--

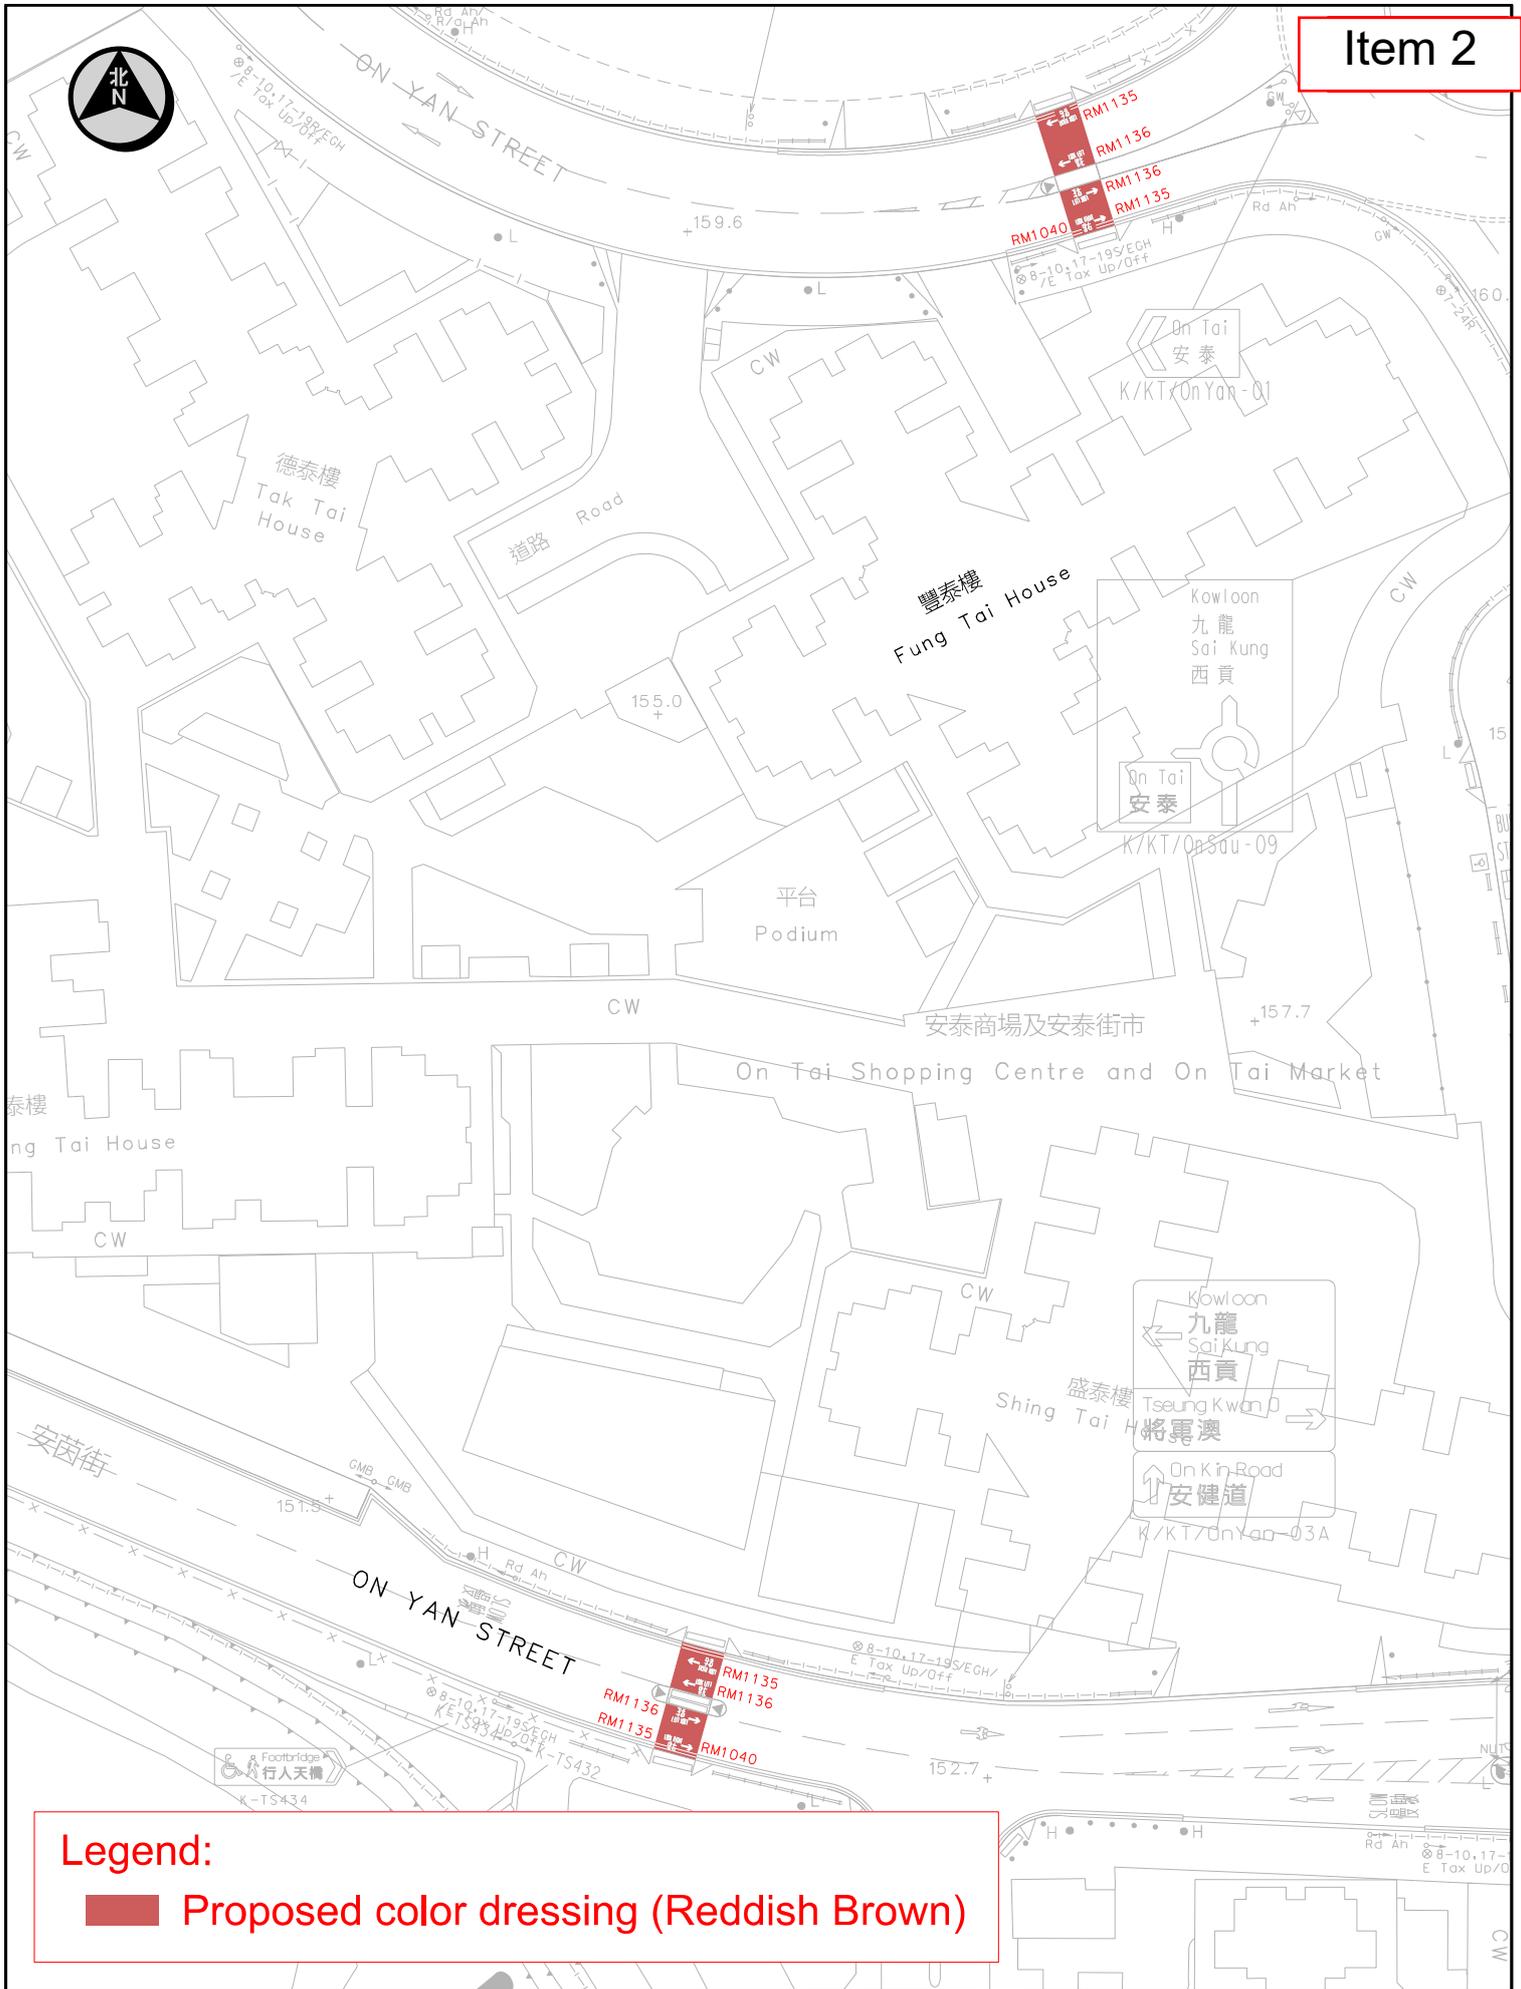

Legend:

■ Proposed color dressing (Reddish Brown)

The drawing shows the approximate location of traffic aids for indication purpose only. The information shown on this drawing should be interpreted by professional engineers. Reproduction by permission only.

Survey Sheet No.:

K11Q13B, 13D

Scale:


1:700 (A4)

Drawing No.:

K240772.01

Date:




8-Aug-2024

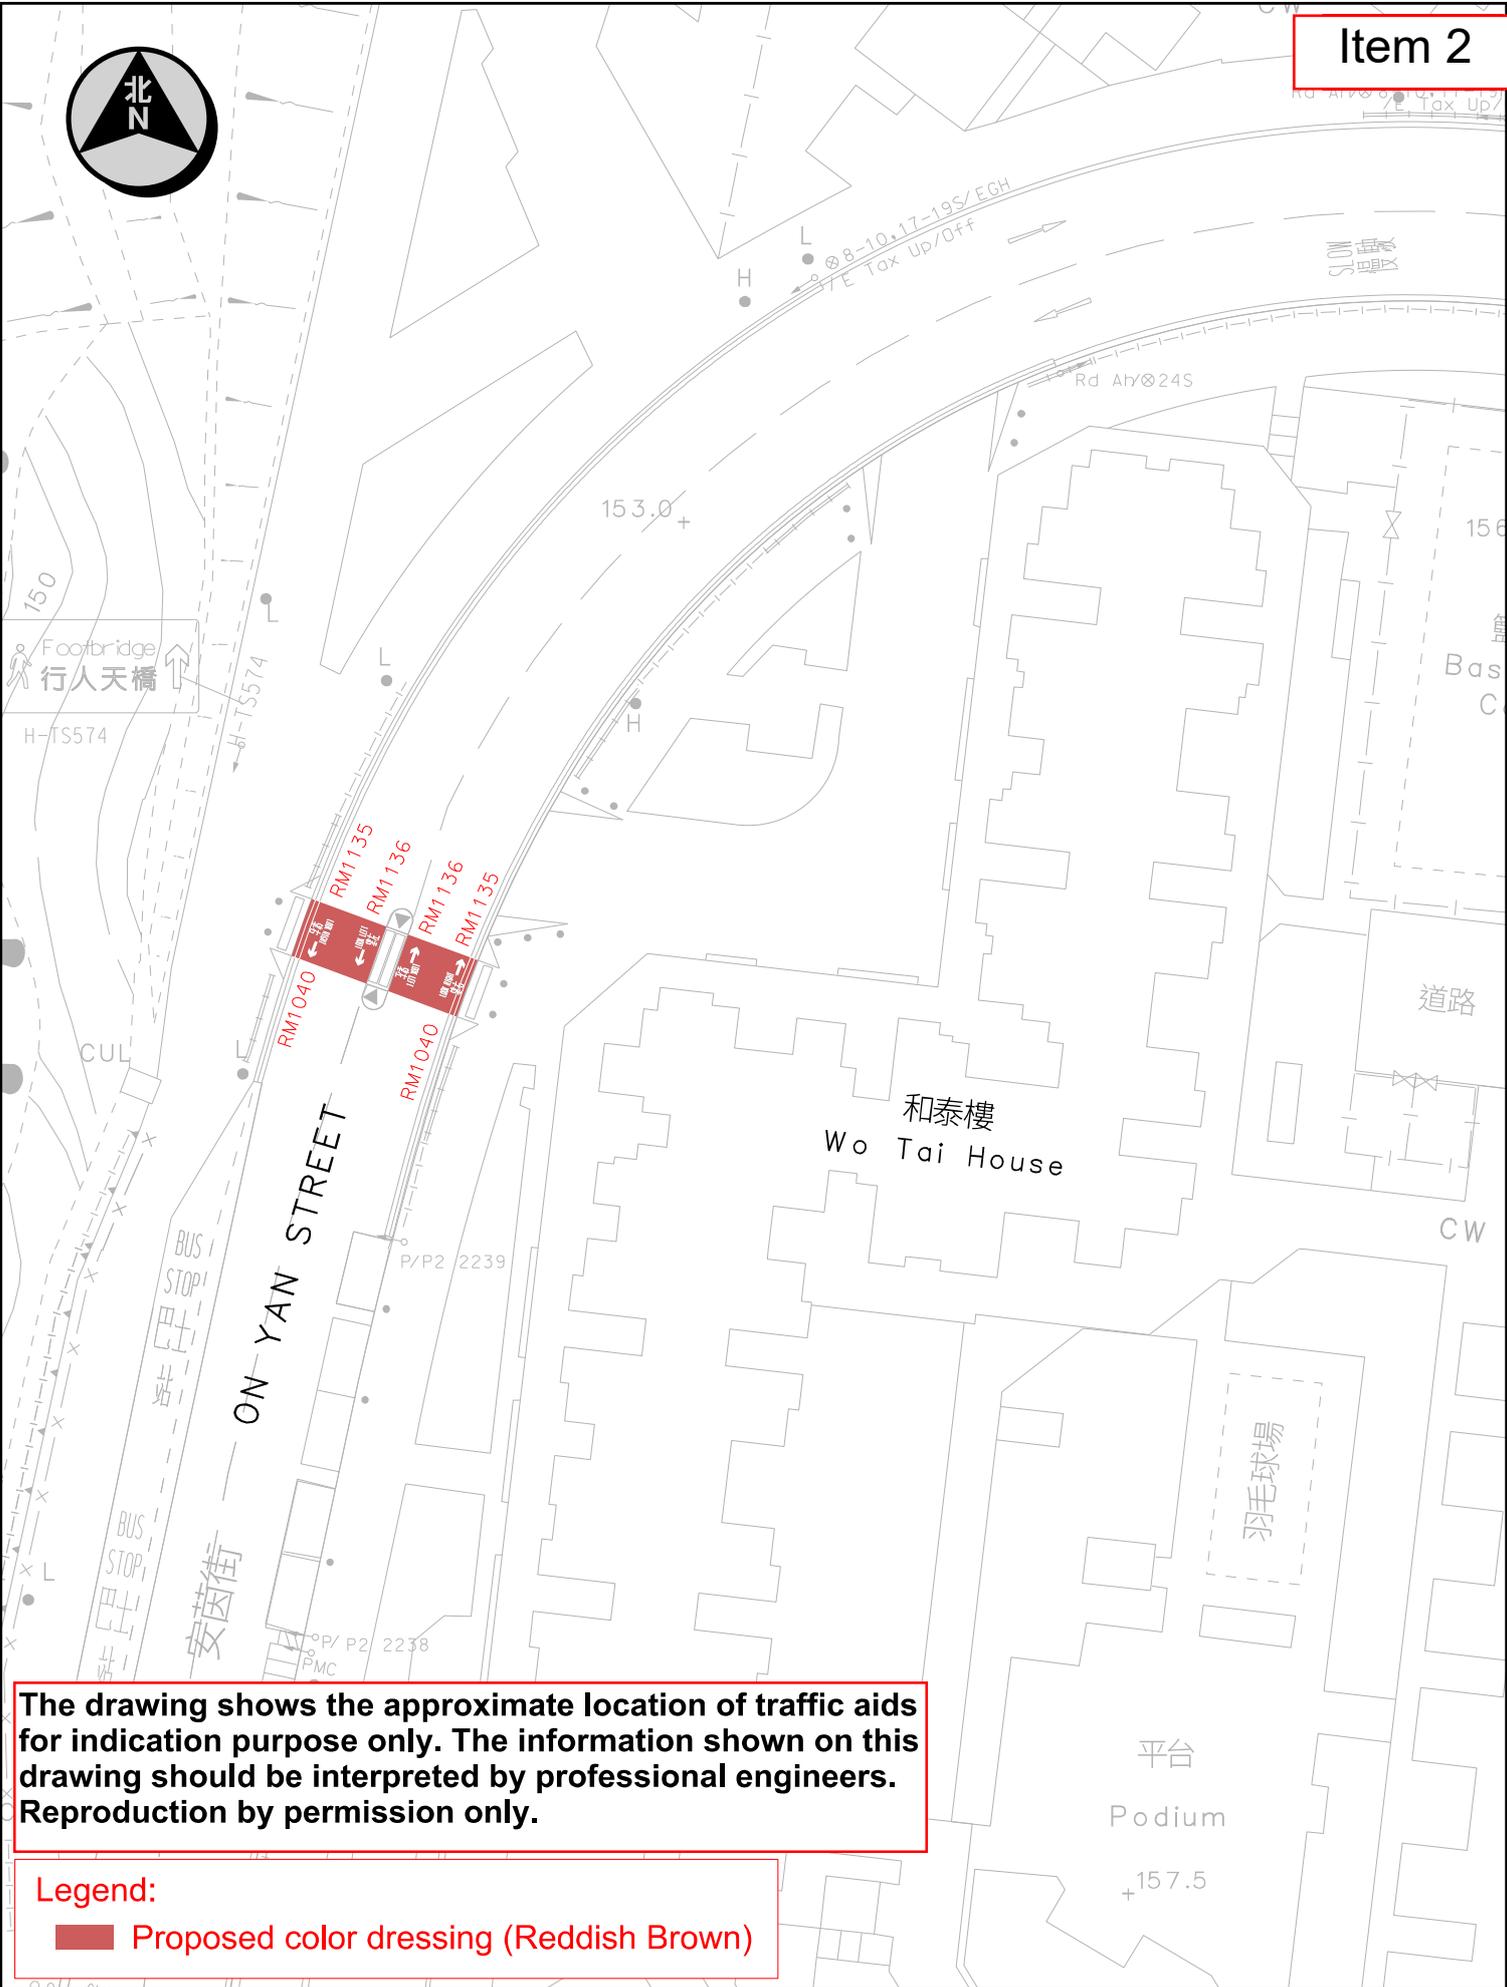

The drawing shows the approximate location of traffic aids for indication purpose only. The information shown on this drawing should be interpreted by professional engineers. Reproduction by permission only.

Legend:
 Proposed color dressing (Reddish Brown)

Location : On Yan Street near Wo Tai House		Survey Sheet No. : K11Q13B, 13D	Scale: 1:500 (A4)
 運輸署 Transport Department	TRAFFIC ENGINEERING (KLN.) DIV.	WRF NO.	Date: 8-Aug-2024
			Drawing No. : K240780.01

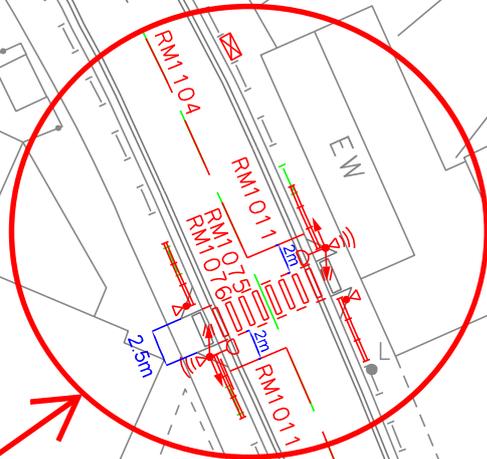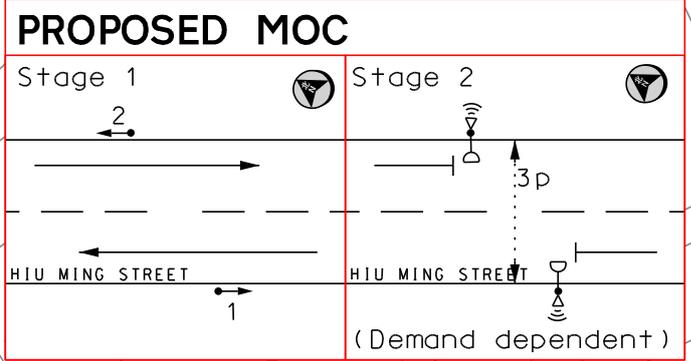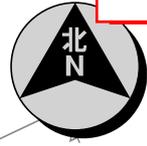


翠楊樓
Tsui Yeung House

TO CARRY OUT TRIAL TRENCHING WORKS

- LEGEND:**
- EXG. R.M. TO BE ERASED
 - PRO. R.M. TO BE PAINTED
 - EXG. AMENITY RAILING TO BE REMOVED
 - PRO. TYPE 2 RAILING AT JUNCTION TO BE INSTALLED
 - PRO. TRAFFIC SIGNAL POSTS WITH TRAFFIC/ PEDESTRIAN ASPECTS/ e-ATS UNITS/ PUSH BUTTON TO BE ERECTED
 - PRO. CONTROLLER TO BE INSTALLED
- (THE EXACT LOCATION TO BE DETERMINED ON SITE BY TCD)

The drawing shows the approximate location of traffic aids for indication purpose only. The information shown on this drawing should be interpreted by professional engineers. Reproduction by permission only.

Survey Sheet No. K11Q18B,18D	Scale 1 : 500 (A4)
Drawing No. K250201.01A (trial pit)	Date 04-03-2025

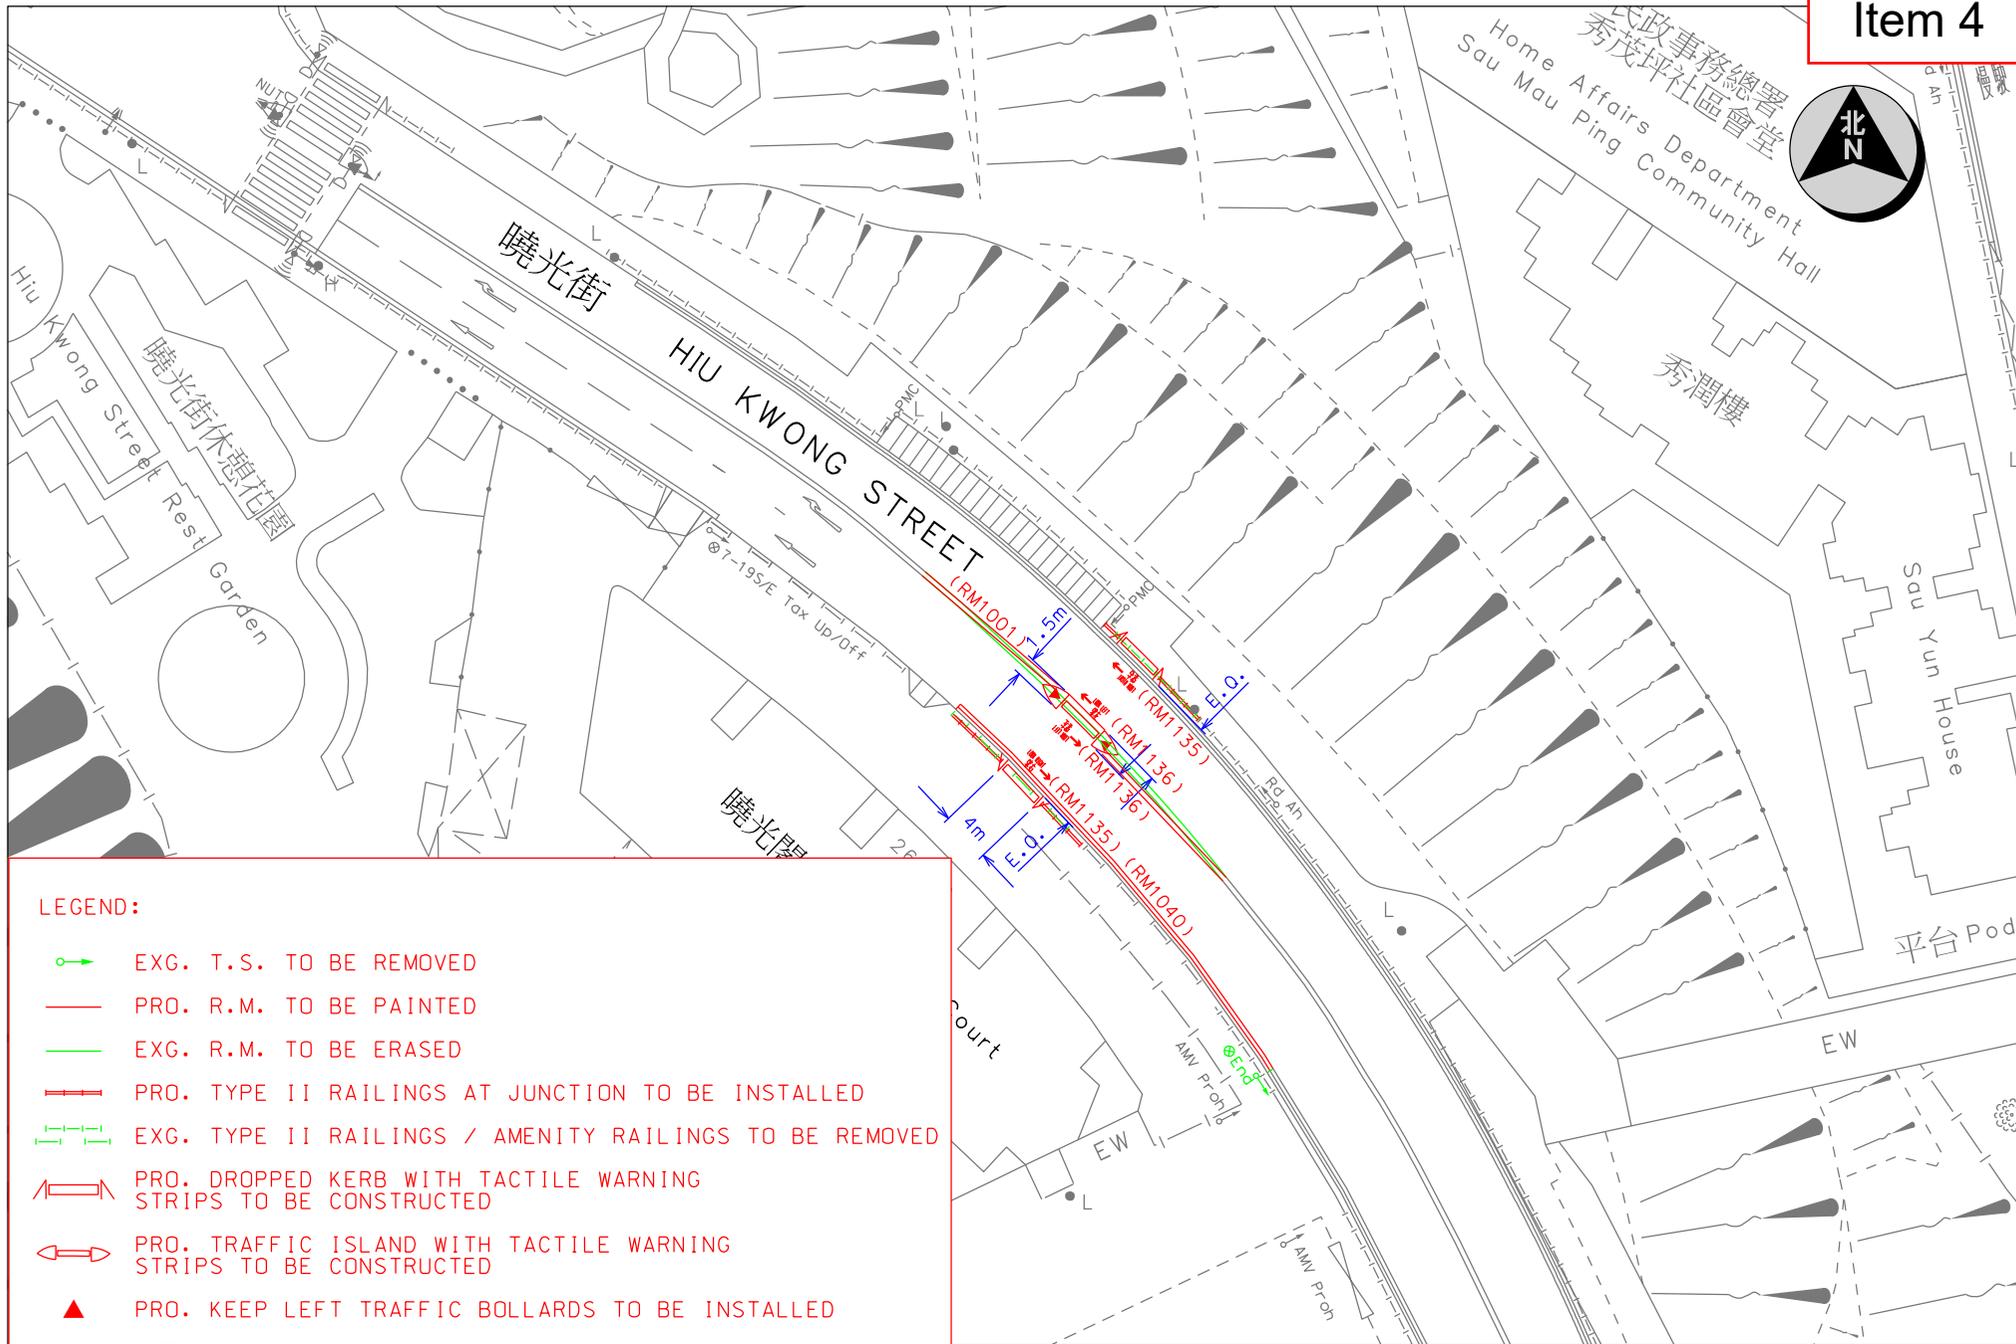

LEGEND:

-  EXG. T.S. TO BE REMOVED
-  PRO. R.M. TO BE PAINTED
-  EXG. R.M. TO BE ERASED
-  PRO. TYPE II RAILINGS AT JUNCTION TO BE INSTALLED
-  EXG. TYPE II RAILINGS / AMENITY RAILINGS TO BE REMOVED
-  PRO. DROPPED KERB WITH TACTILE WARNING STRIPS TO BE CONSTRUCTED
-  PRO. TRAFFIC ISLAND WITH TACTILE WARNING STRIPS TO BE CONSTRUCTED
-  PRO. KEEP LEFT TRAFFIC BOLLARDS TO BE INSTALLED



TRAFFIC ENGINEERING
(KLN.) DIV.

Location : Hiu Kwong Street near Hiu Kwong Court


Survey Sheet No. : K11Q18B

Scale: 1:600 (A4)


Drawing No. : K250714.01

WRF NO. WR/HY/TE/KL/25/01253

Date : 10-07-2025

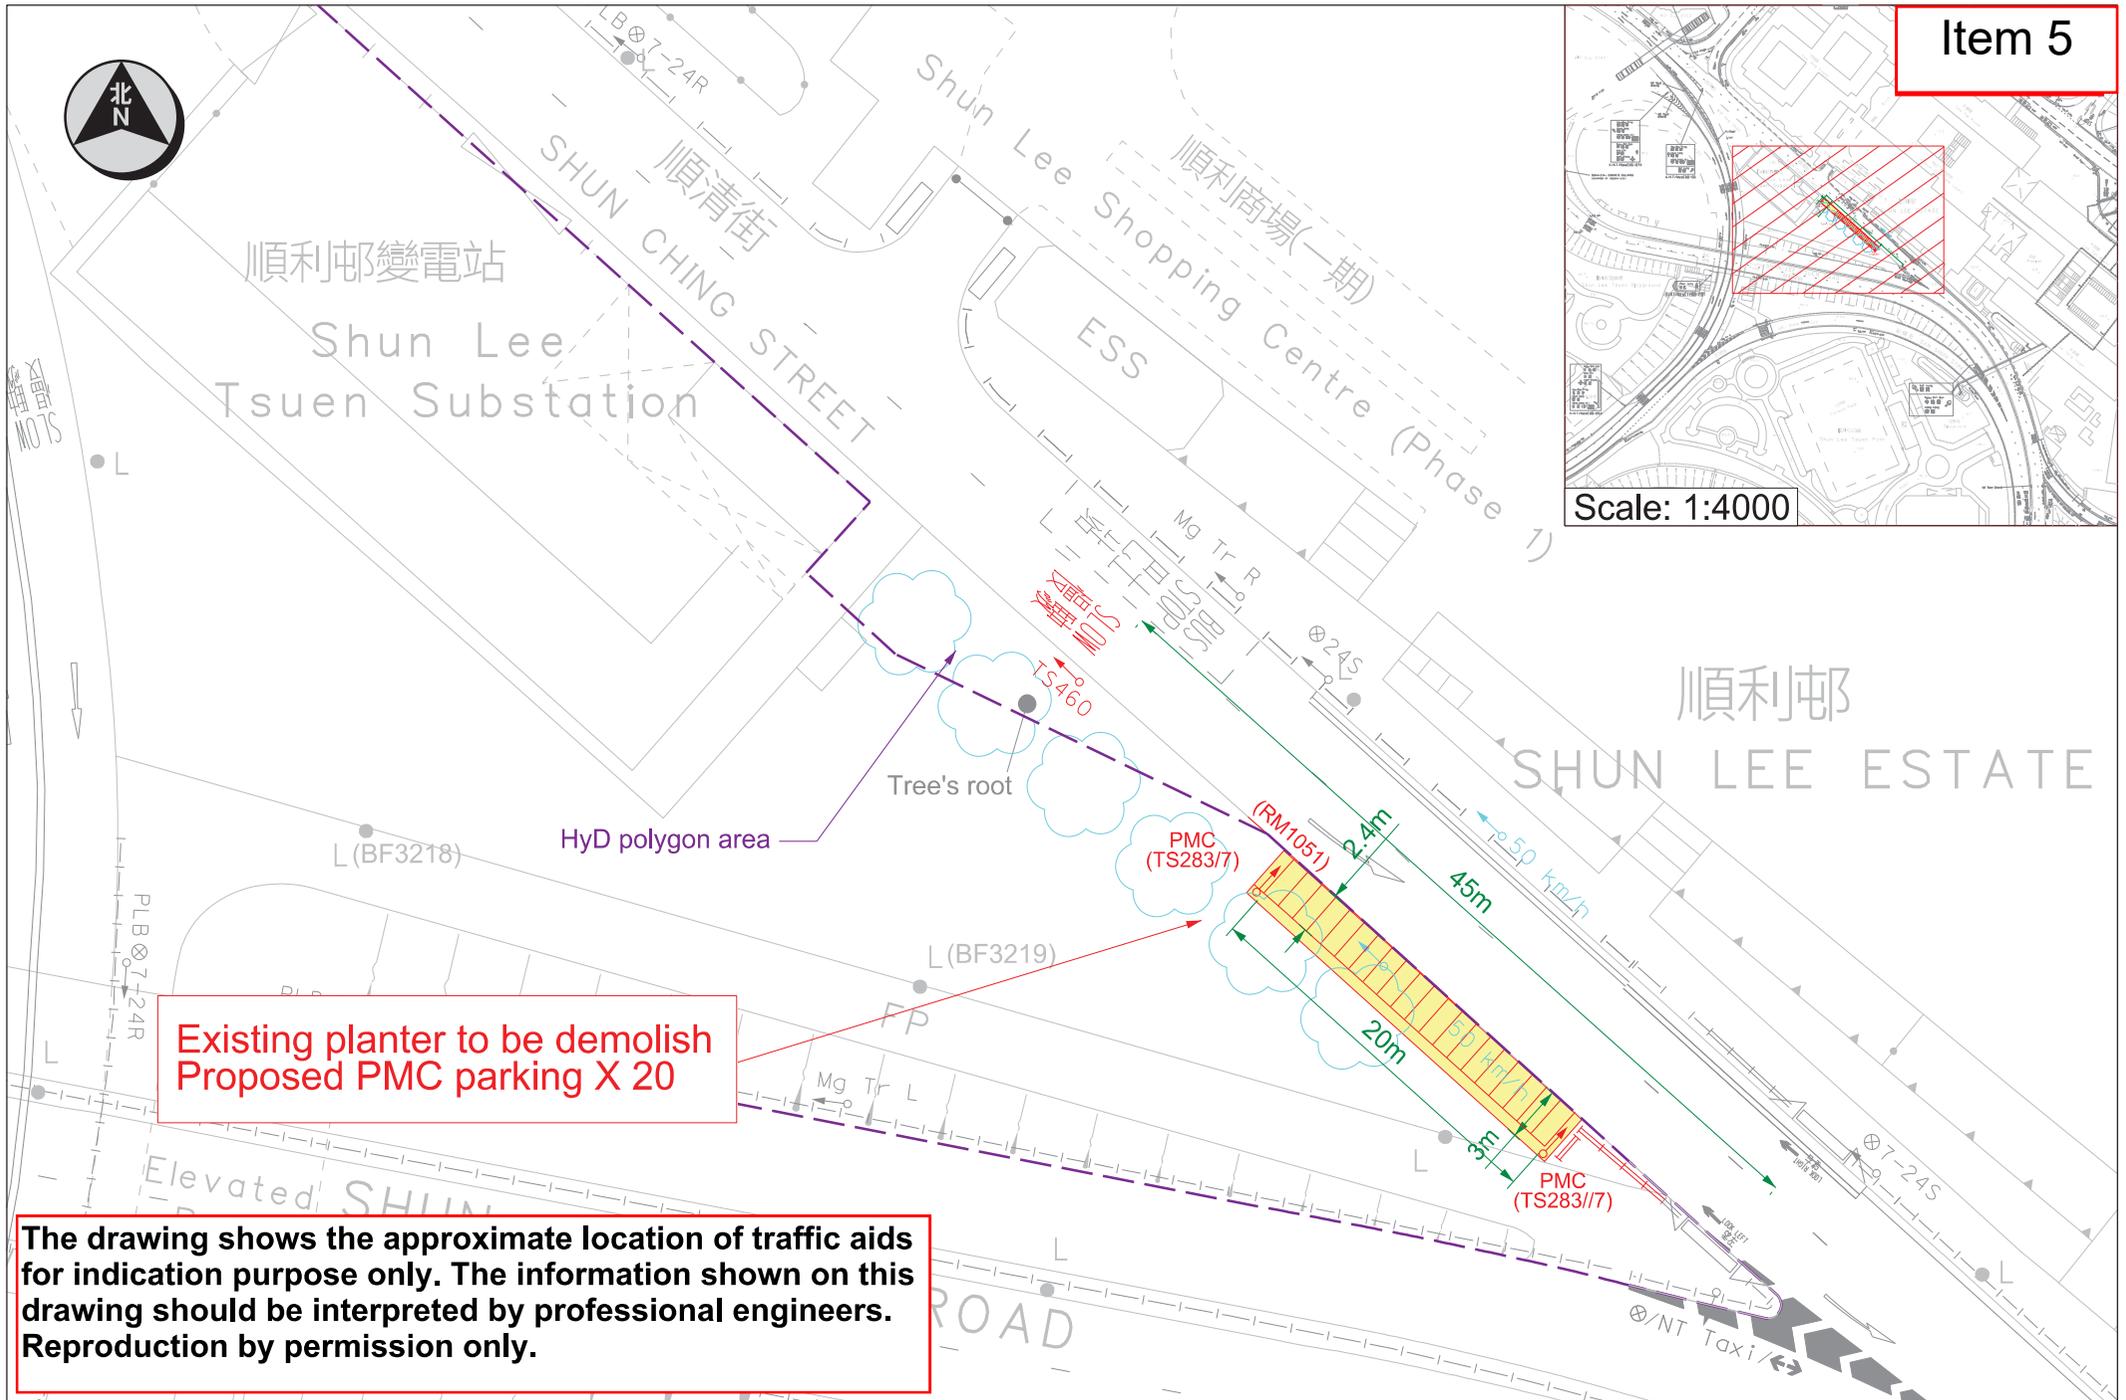

The drawing shows the approximate location of traffic aids for indication purpose only. The information shown on this drawing should be interpreted by professional engineers. Reproduction by permission only.

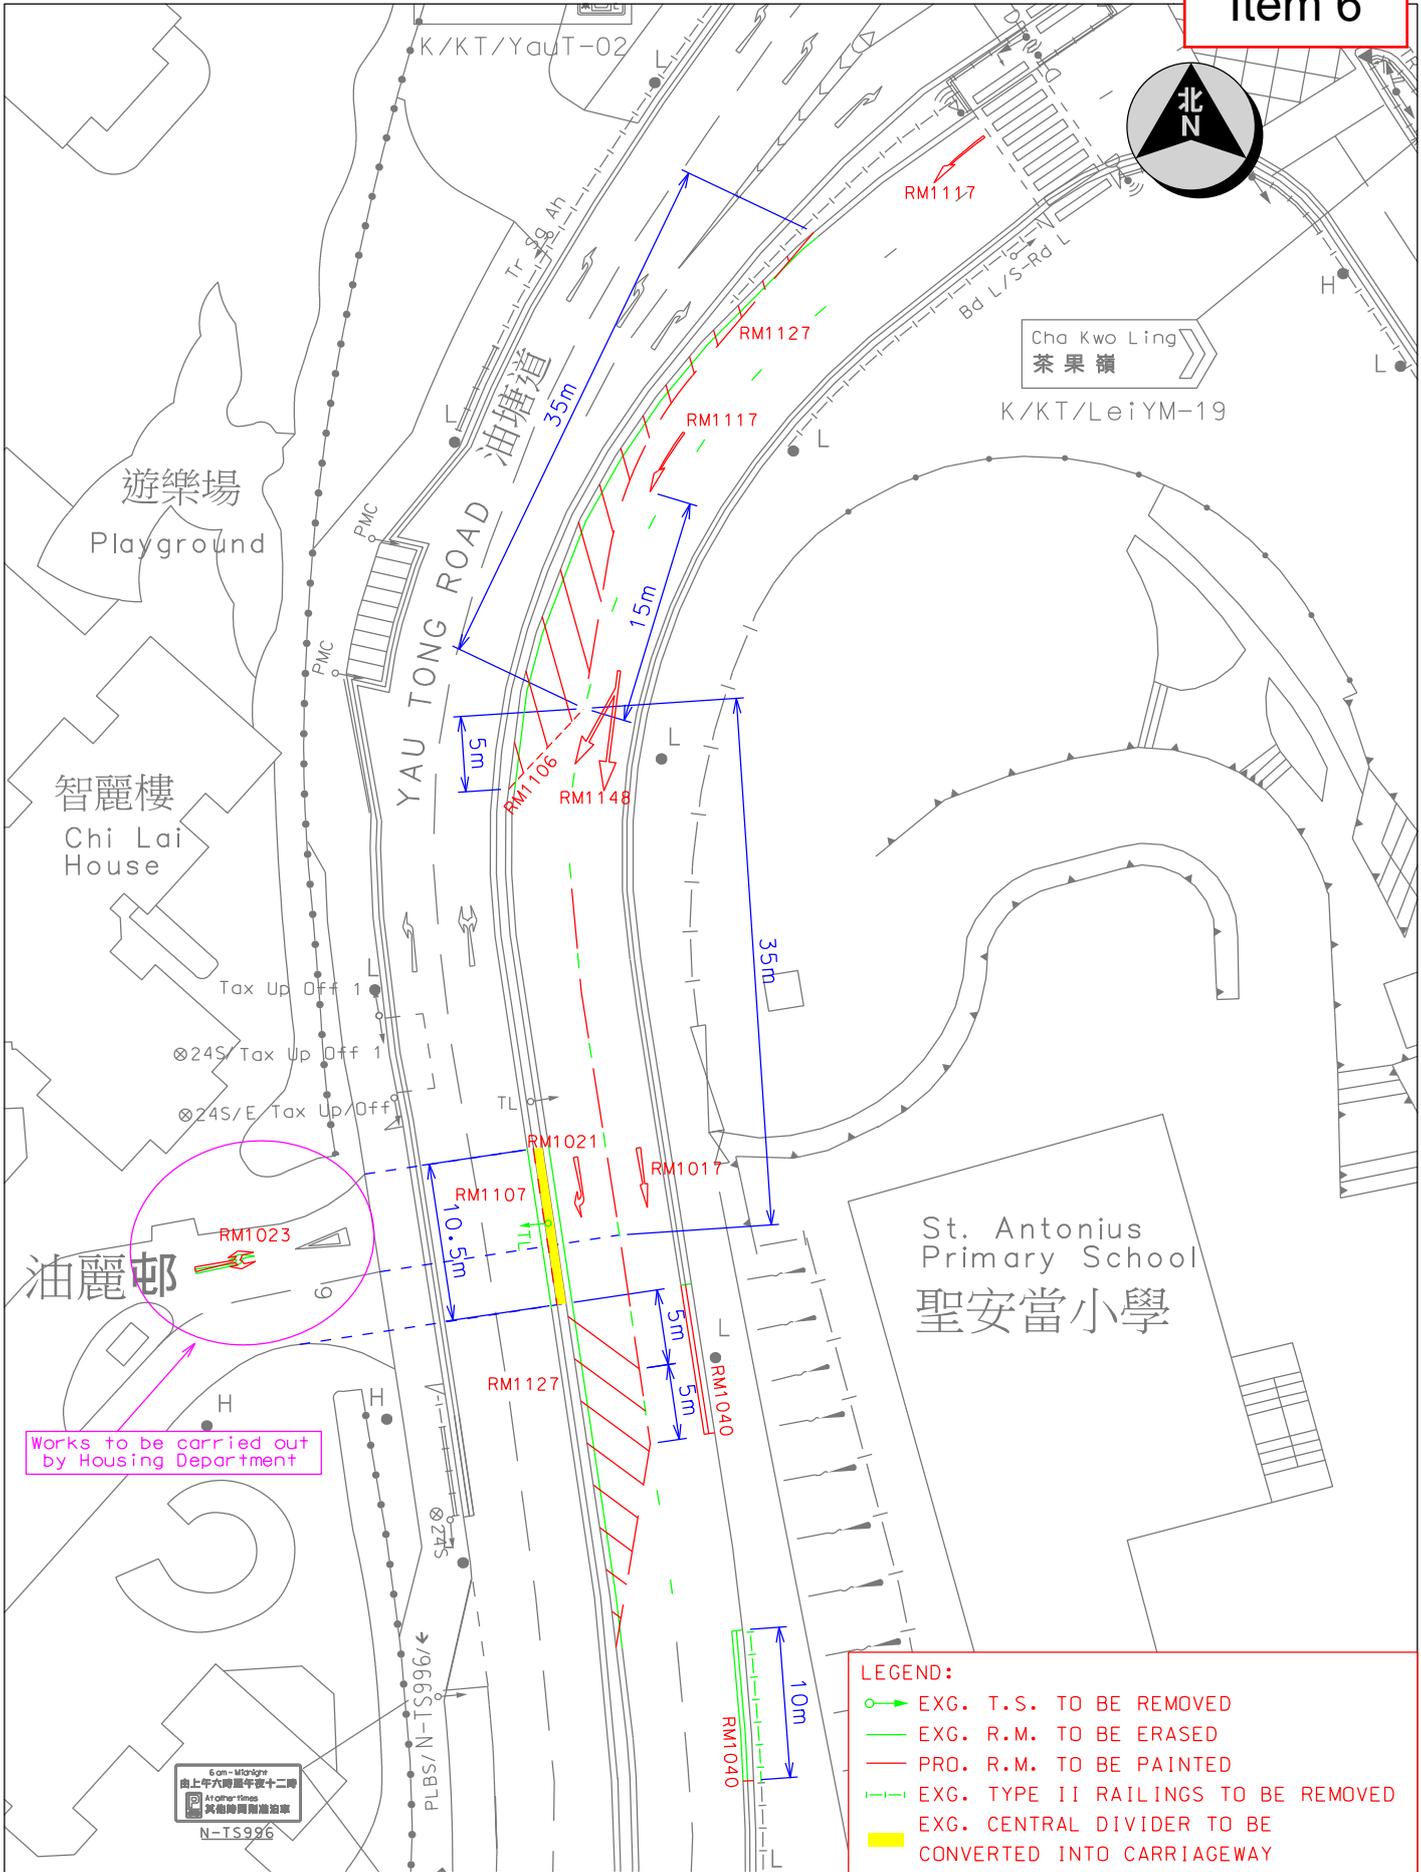

Survey Sheet No.
K11Q24C

Scale
1 : 500 (A4)




TRAFFIC ENGINEERING
(KLN.) DIV.

WRF NO.
WR/HY/TE/KL/25/01251


Drawing No.
K240557.01A

Date
03-09-2025

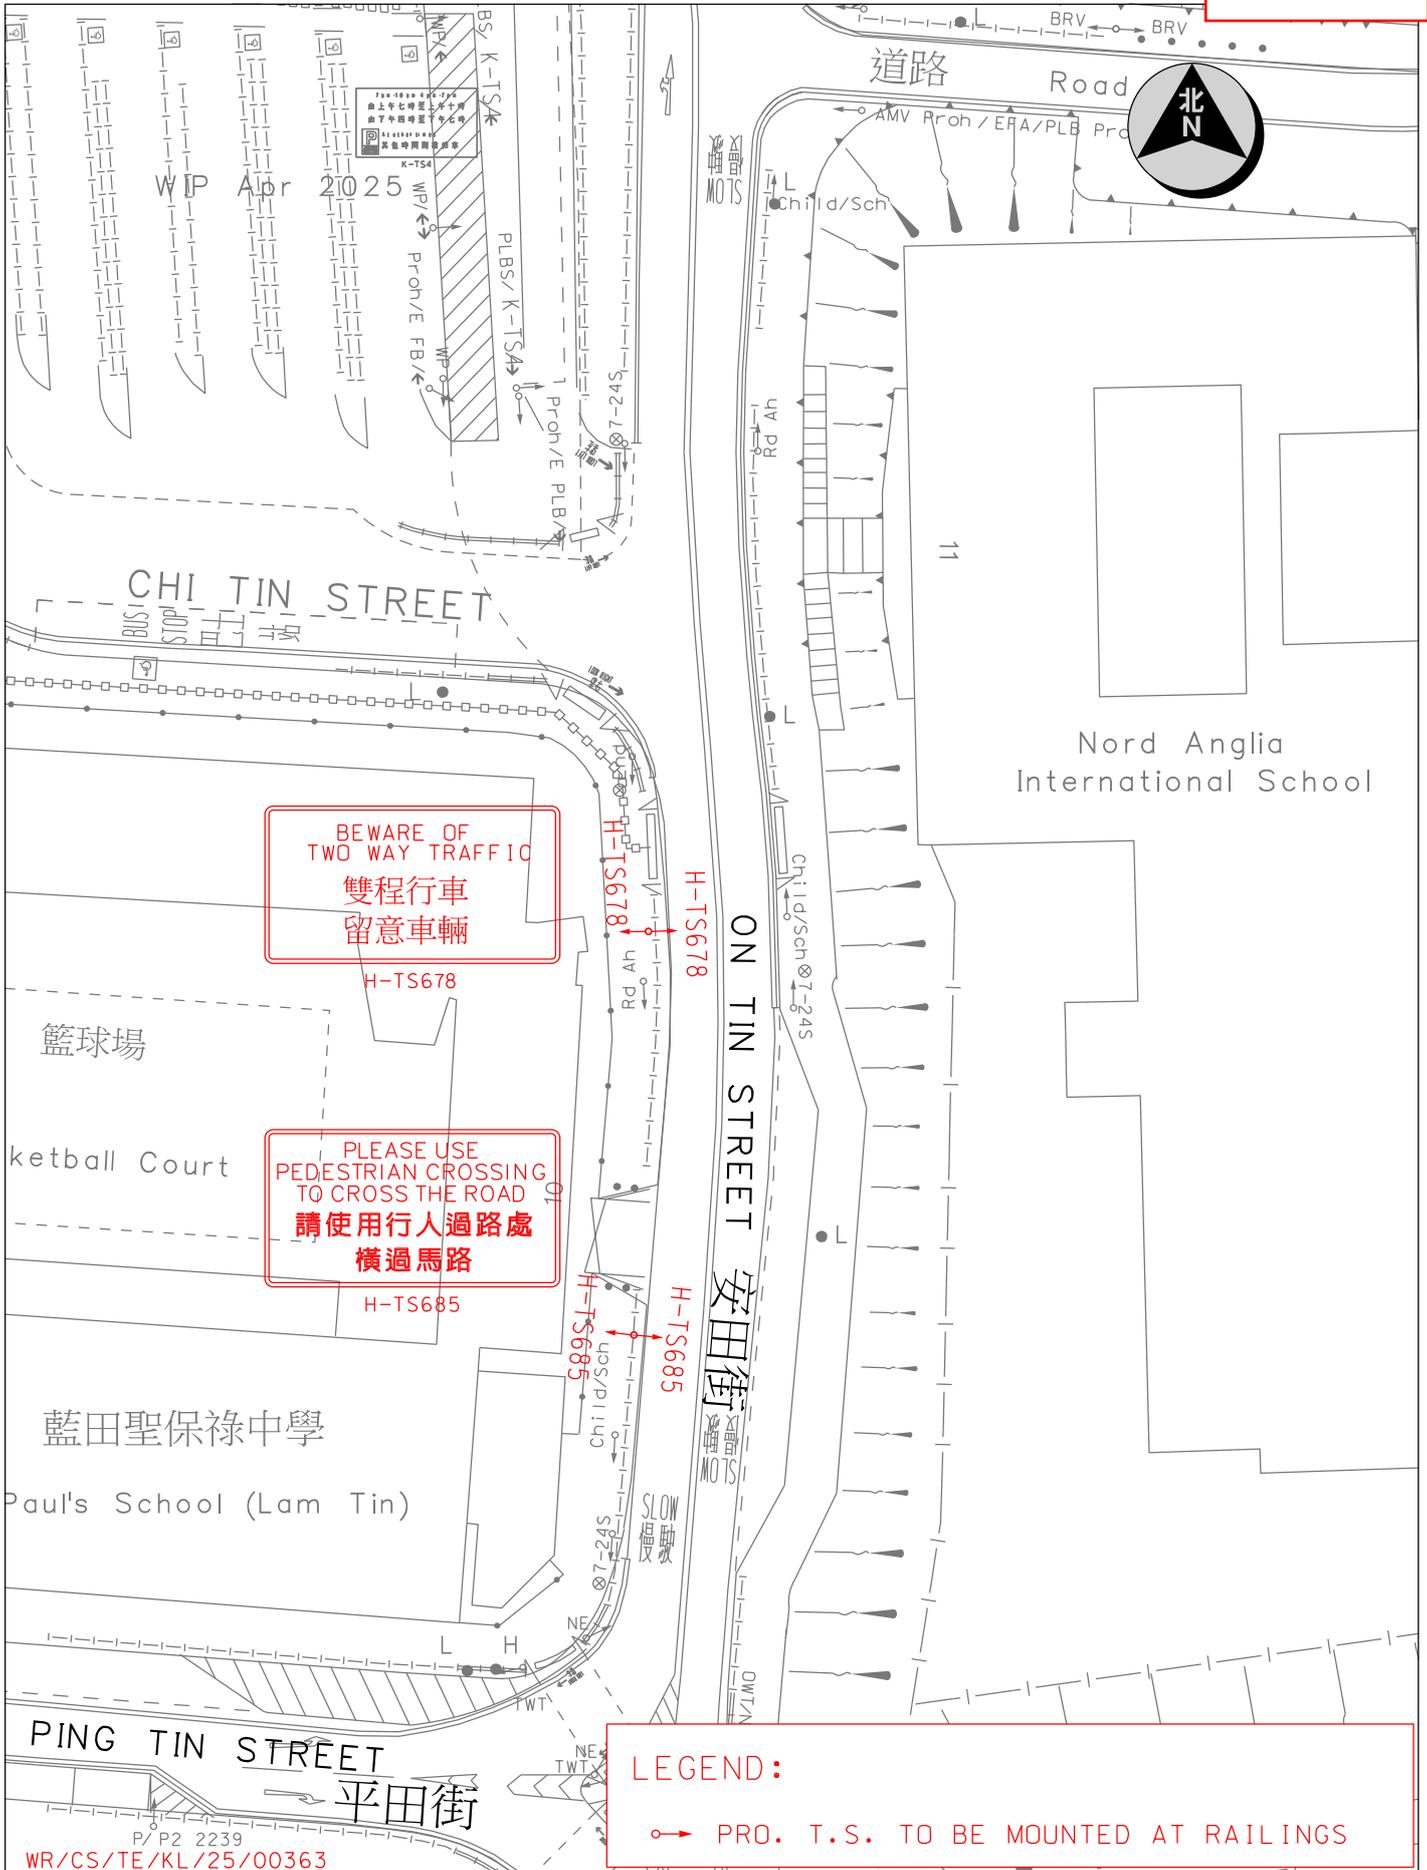

WR/CS/TE/KL/25/00363

Location : On Tin Street near Ping Tin Street		Survey Sheet No. K11Q24A	Scale 1 : 500 (A4)
 <p>運輸署 Transport Department</p>	TRAFFIC ENGINEERING (KLN.) DIV.	WRF NO. WR/HY/TE/KL/25/01661	Drawing No. K250938.01
			Date 9-9-2025

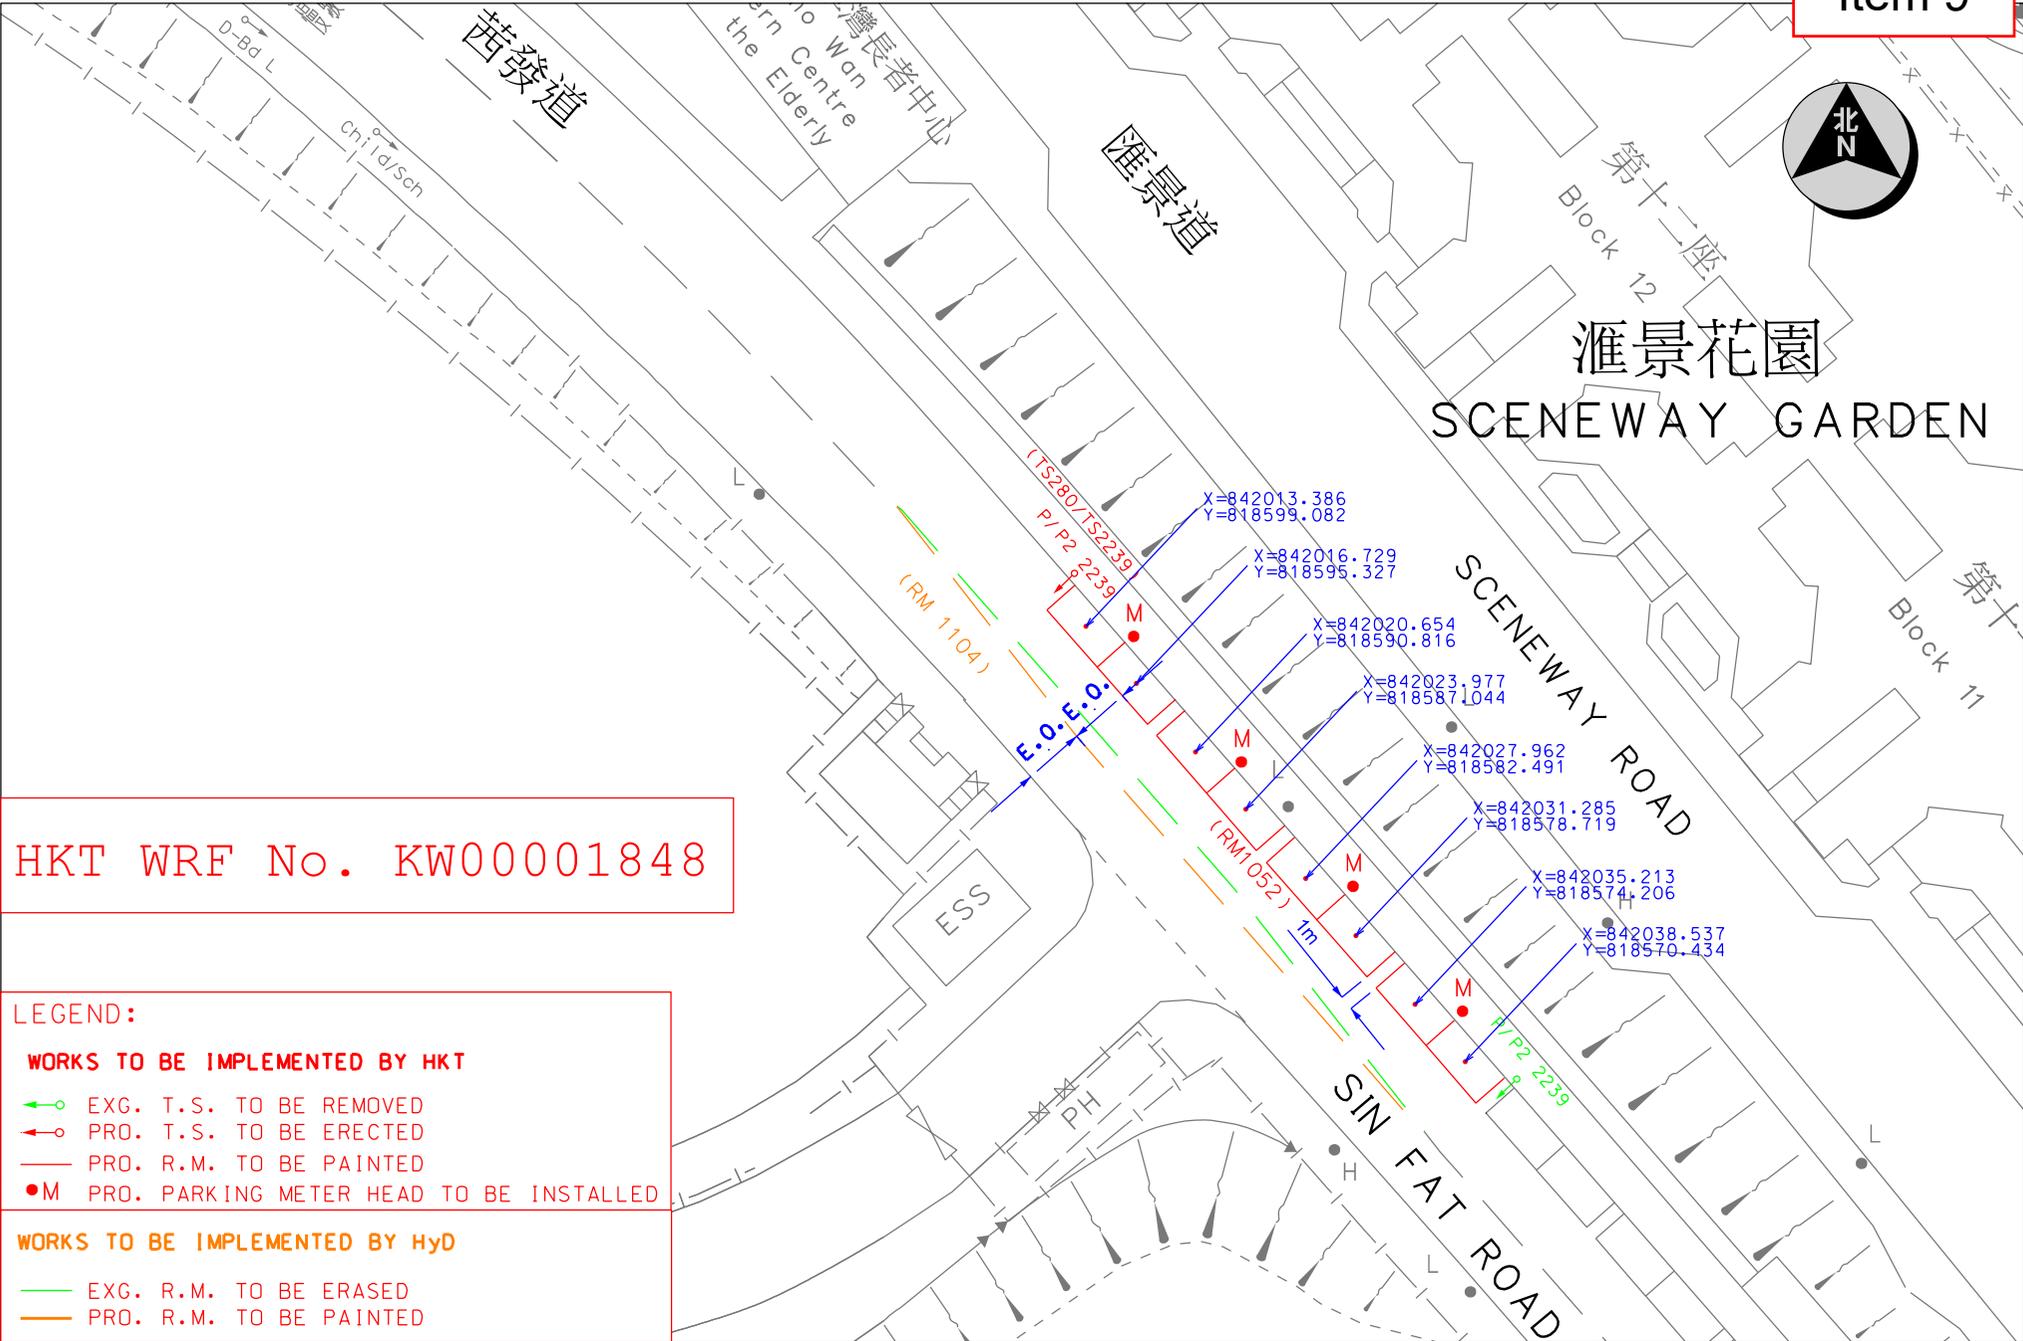

HKT WRF No. KW00001848

- LEGEND:**
- WORKS TO BE IMPLEMENTED BY HKT**
- EXG. T.S. TO BE REMOVED
 - PRO. T.S. TO BE ERRECTED
 - PRO. R.M. TO BE PAINTED
 - PRO. PARKING METER HEAD TO BE INSTALLED

- WORKS TO BE IMPLEMENTED BY HyD**
- EXG. R.M. TO BE ERASED
 - PRO. R.M. TO BE PAINTED



TRAFFIC ENGINEERING
(KLN.) DIV.

Location : Sin Fat Road
Survey Sheet No. : K11Q23D

Scale: 1:500 (A4)

Drawing No. : K250854.03

WRF NO. WR/HY/TE/KL/25/01588
Date : 12-09-2025



順利紀律部隊宿舍


Shun Lee Disciplined Services Quarters

第七座
Block 7

第八座
Block 8

順利消防局

Shun Lee Fire Station

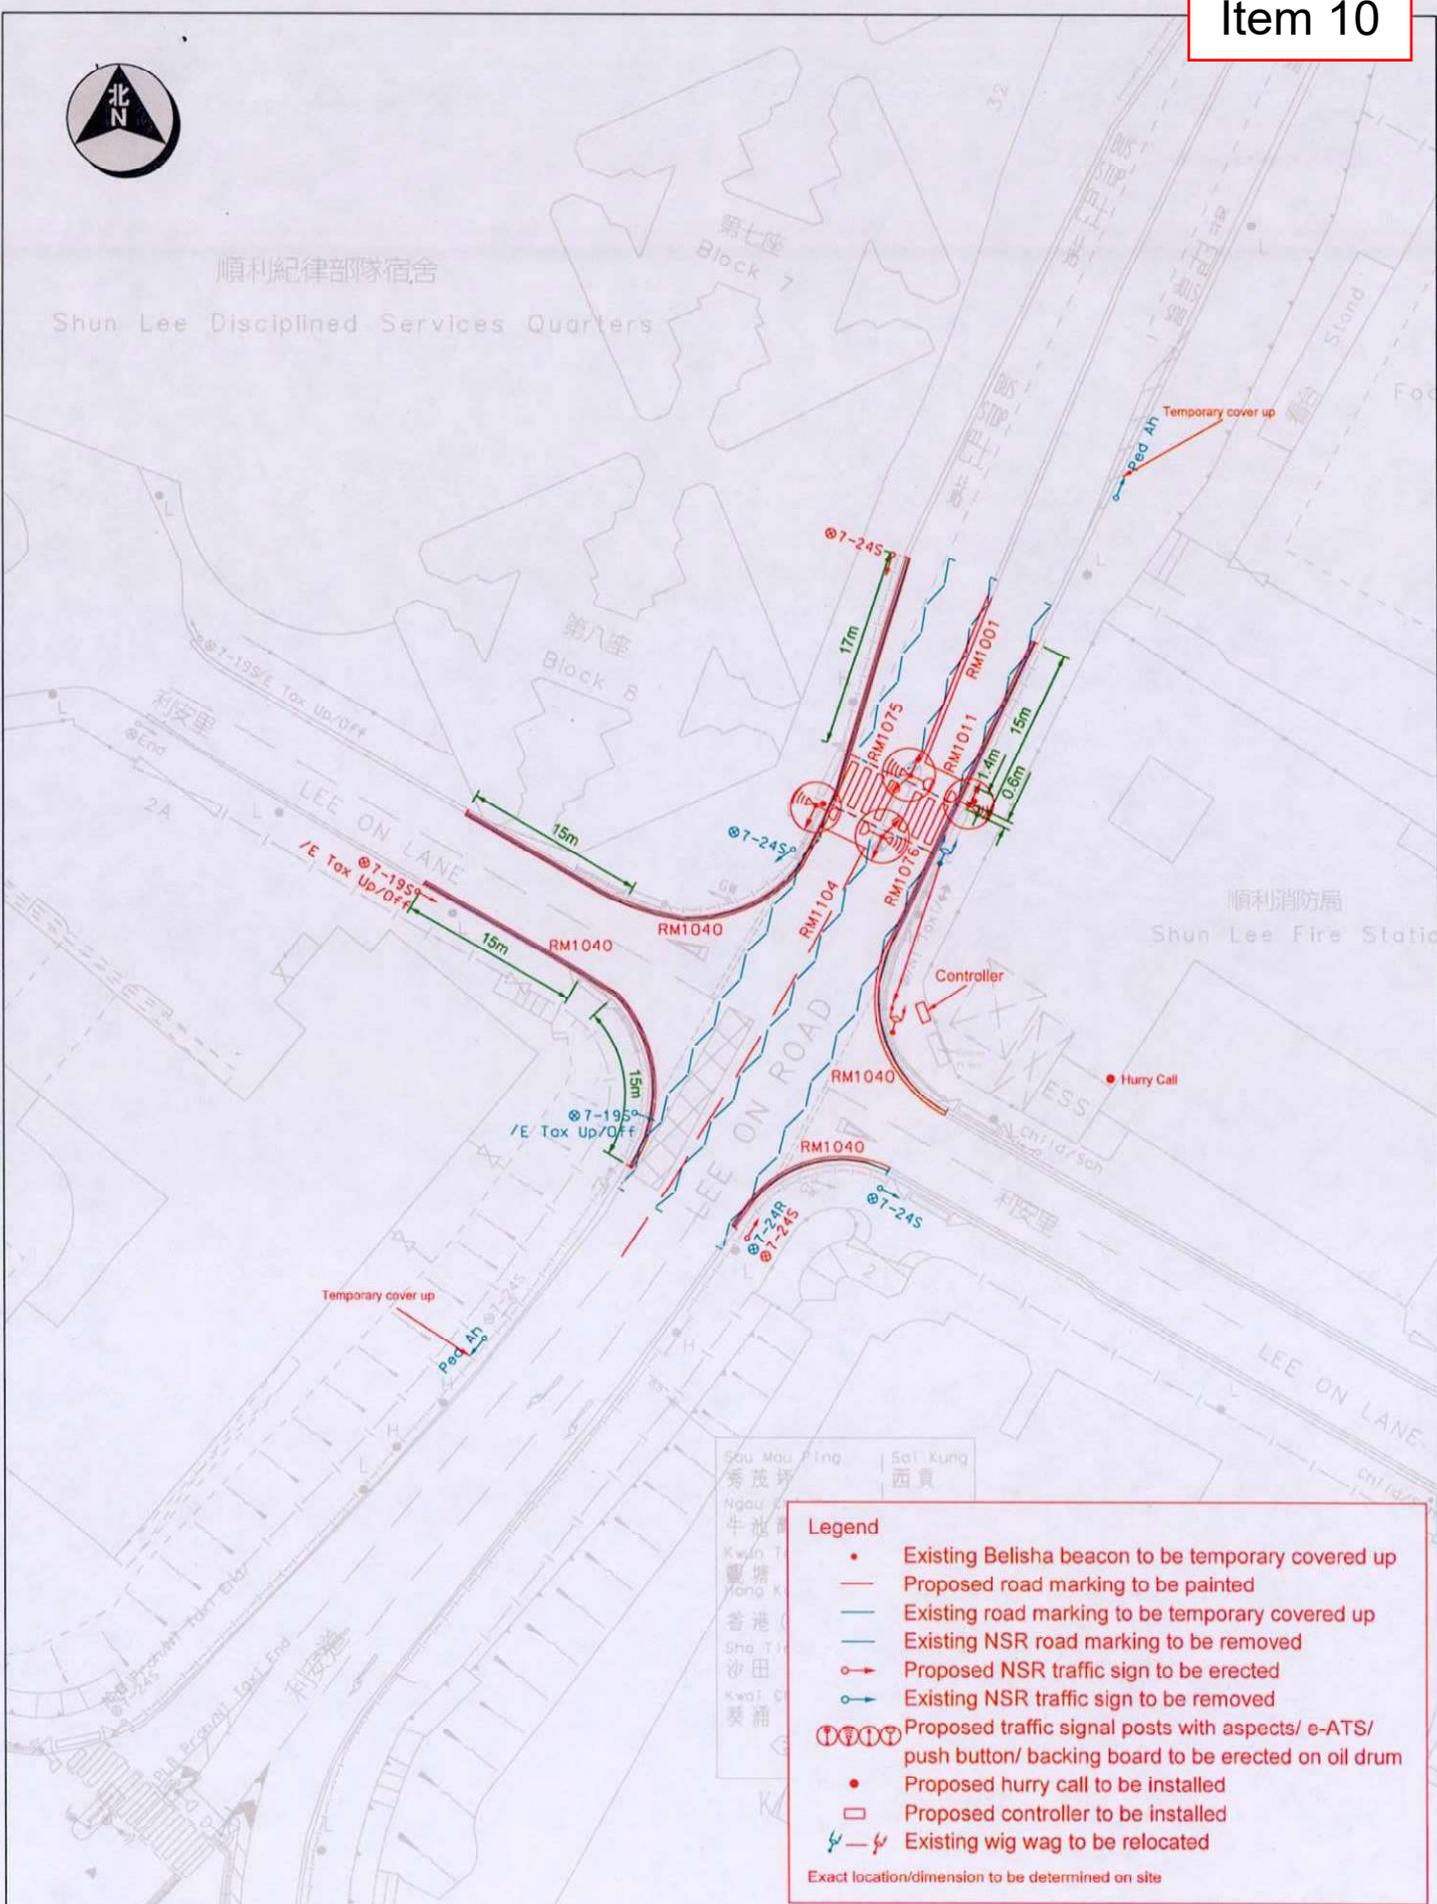


Legend

- Existing Belisha beacon to be temporary covered up
- Proposed road marking to be painted
- Existing road marking to be temporary covered up
- Existing NSR road marking to be removed
- ◀ Proposed NSR traffic sign to be erected
- ◀ Existing NSR traffic sign to be removed
- ⓪⓪⓪⓪ Proposed traffic signal posts with aspects/ e-ATS/ push button/ backing board to be erected on oil drum
- Proposed hurry call to be installed
- ◻ Proposed controller to be installed
- ↔ Existing wig wag to be relocated


Exact location/dimension to be determined on site

Location : Lee On Road near Lee On Lane		Survey Sheet No. K11Q13A	Scale: 1 : 600 (A4)
 <p>運輸署 Transport Department</p>	TRAFFIC ENGINEERING (KLN.) DIV.	WRF NO. WR/HY/TE/KL/25/00109 WR/EM/TE/KL/25/00012	Drawing No. K231396.01E
			Date 28 Feb 2025

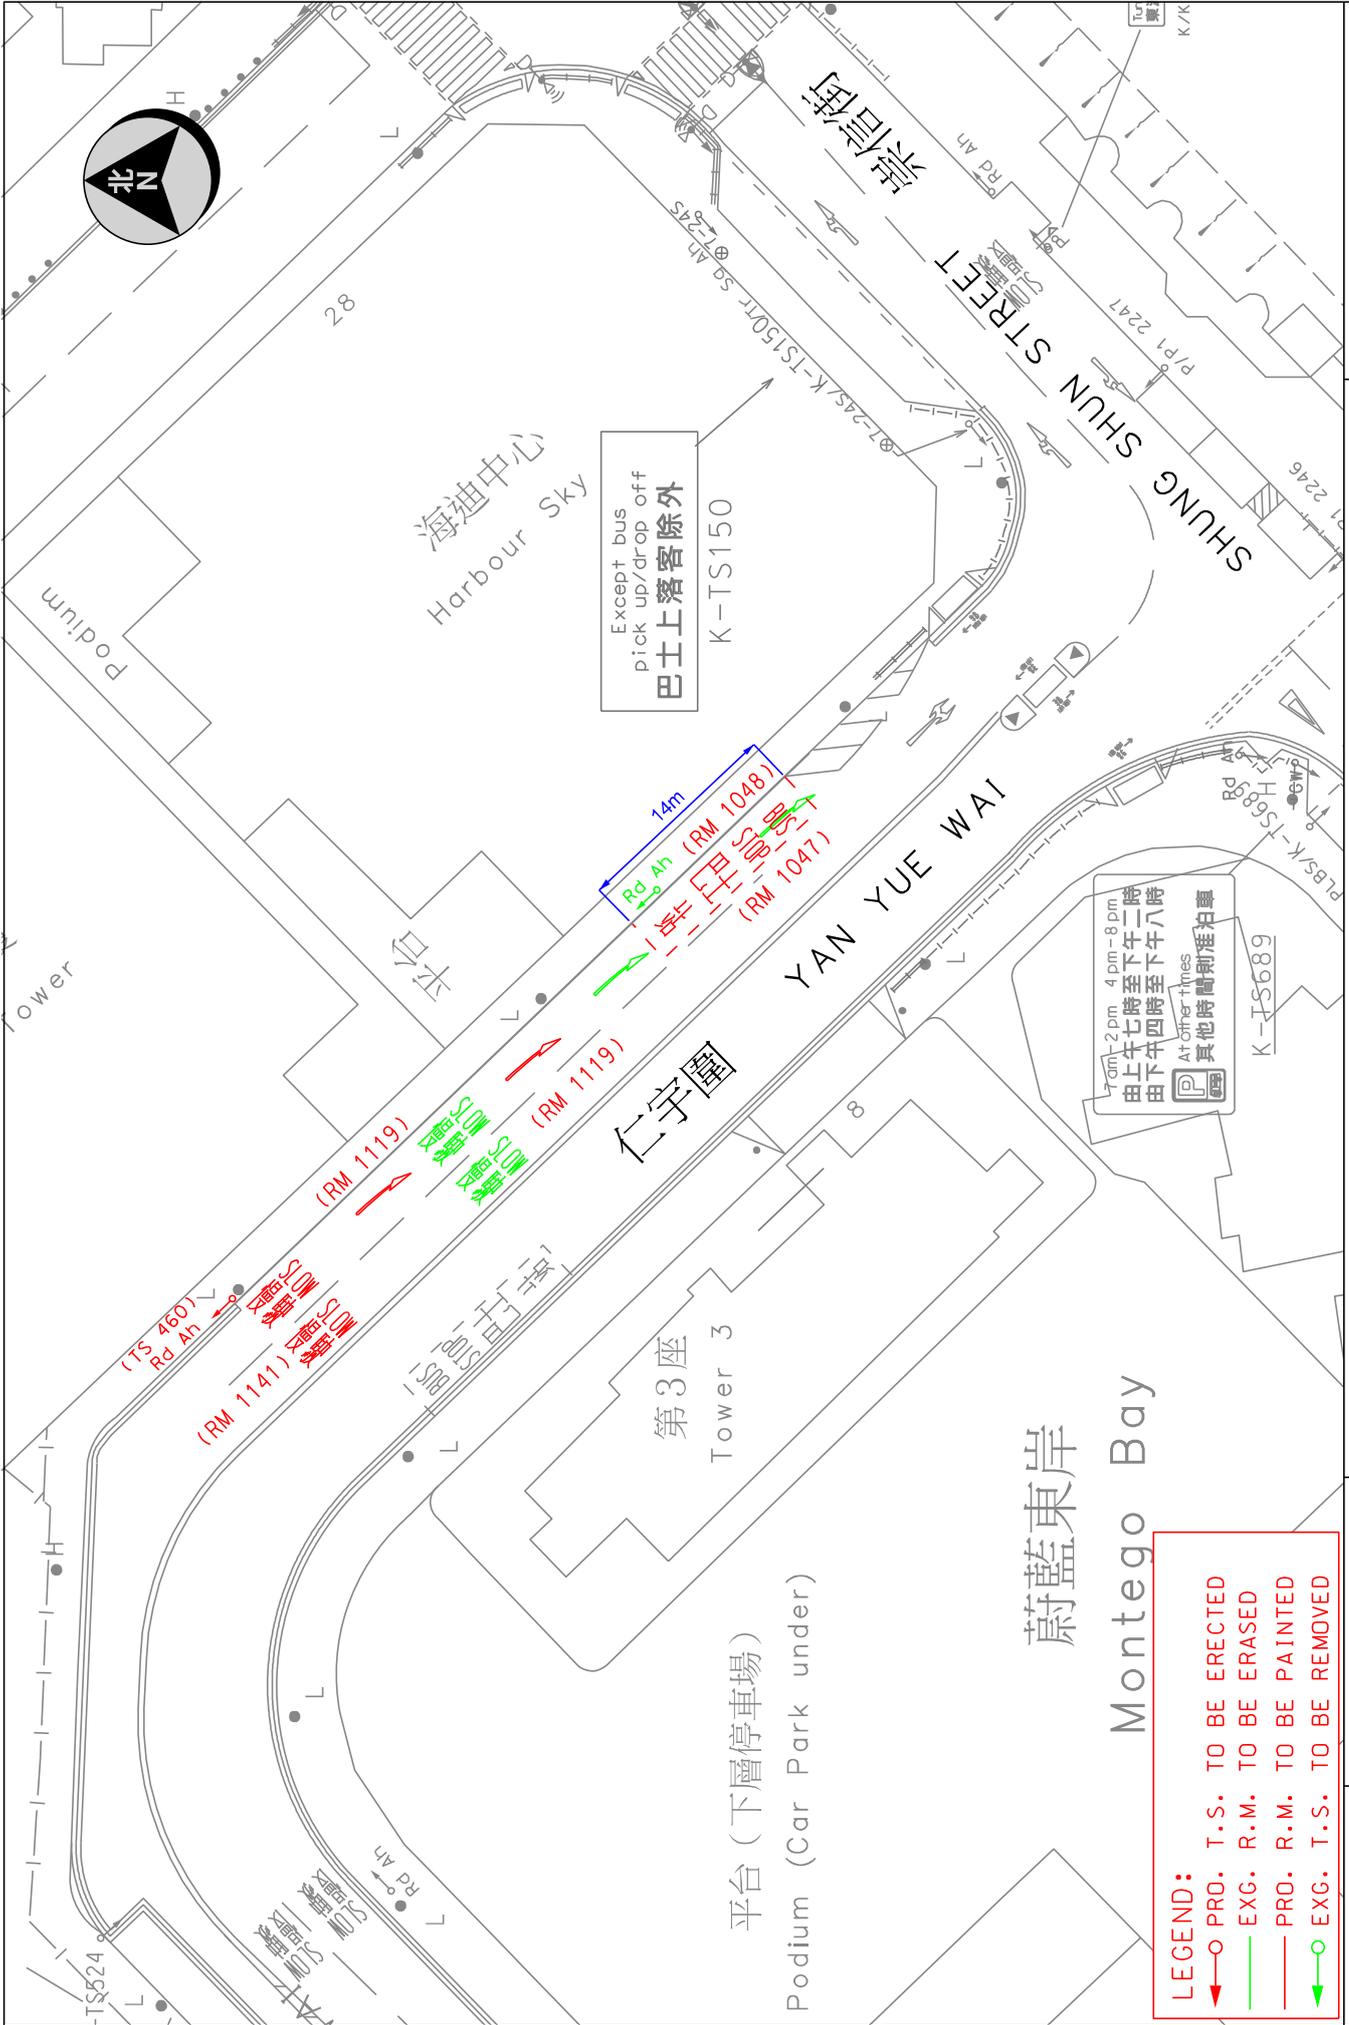


LEGEND:

- PRO. T.S. TO BE ERECTED
- EXG. R.M. TO BE ERASED
- PRO. R.M. TO BE PAINTED
- EXG. T.S. TO BE REMOVED

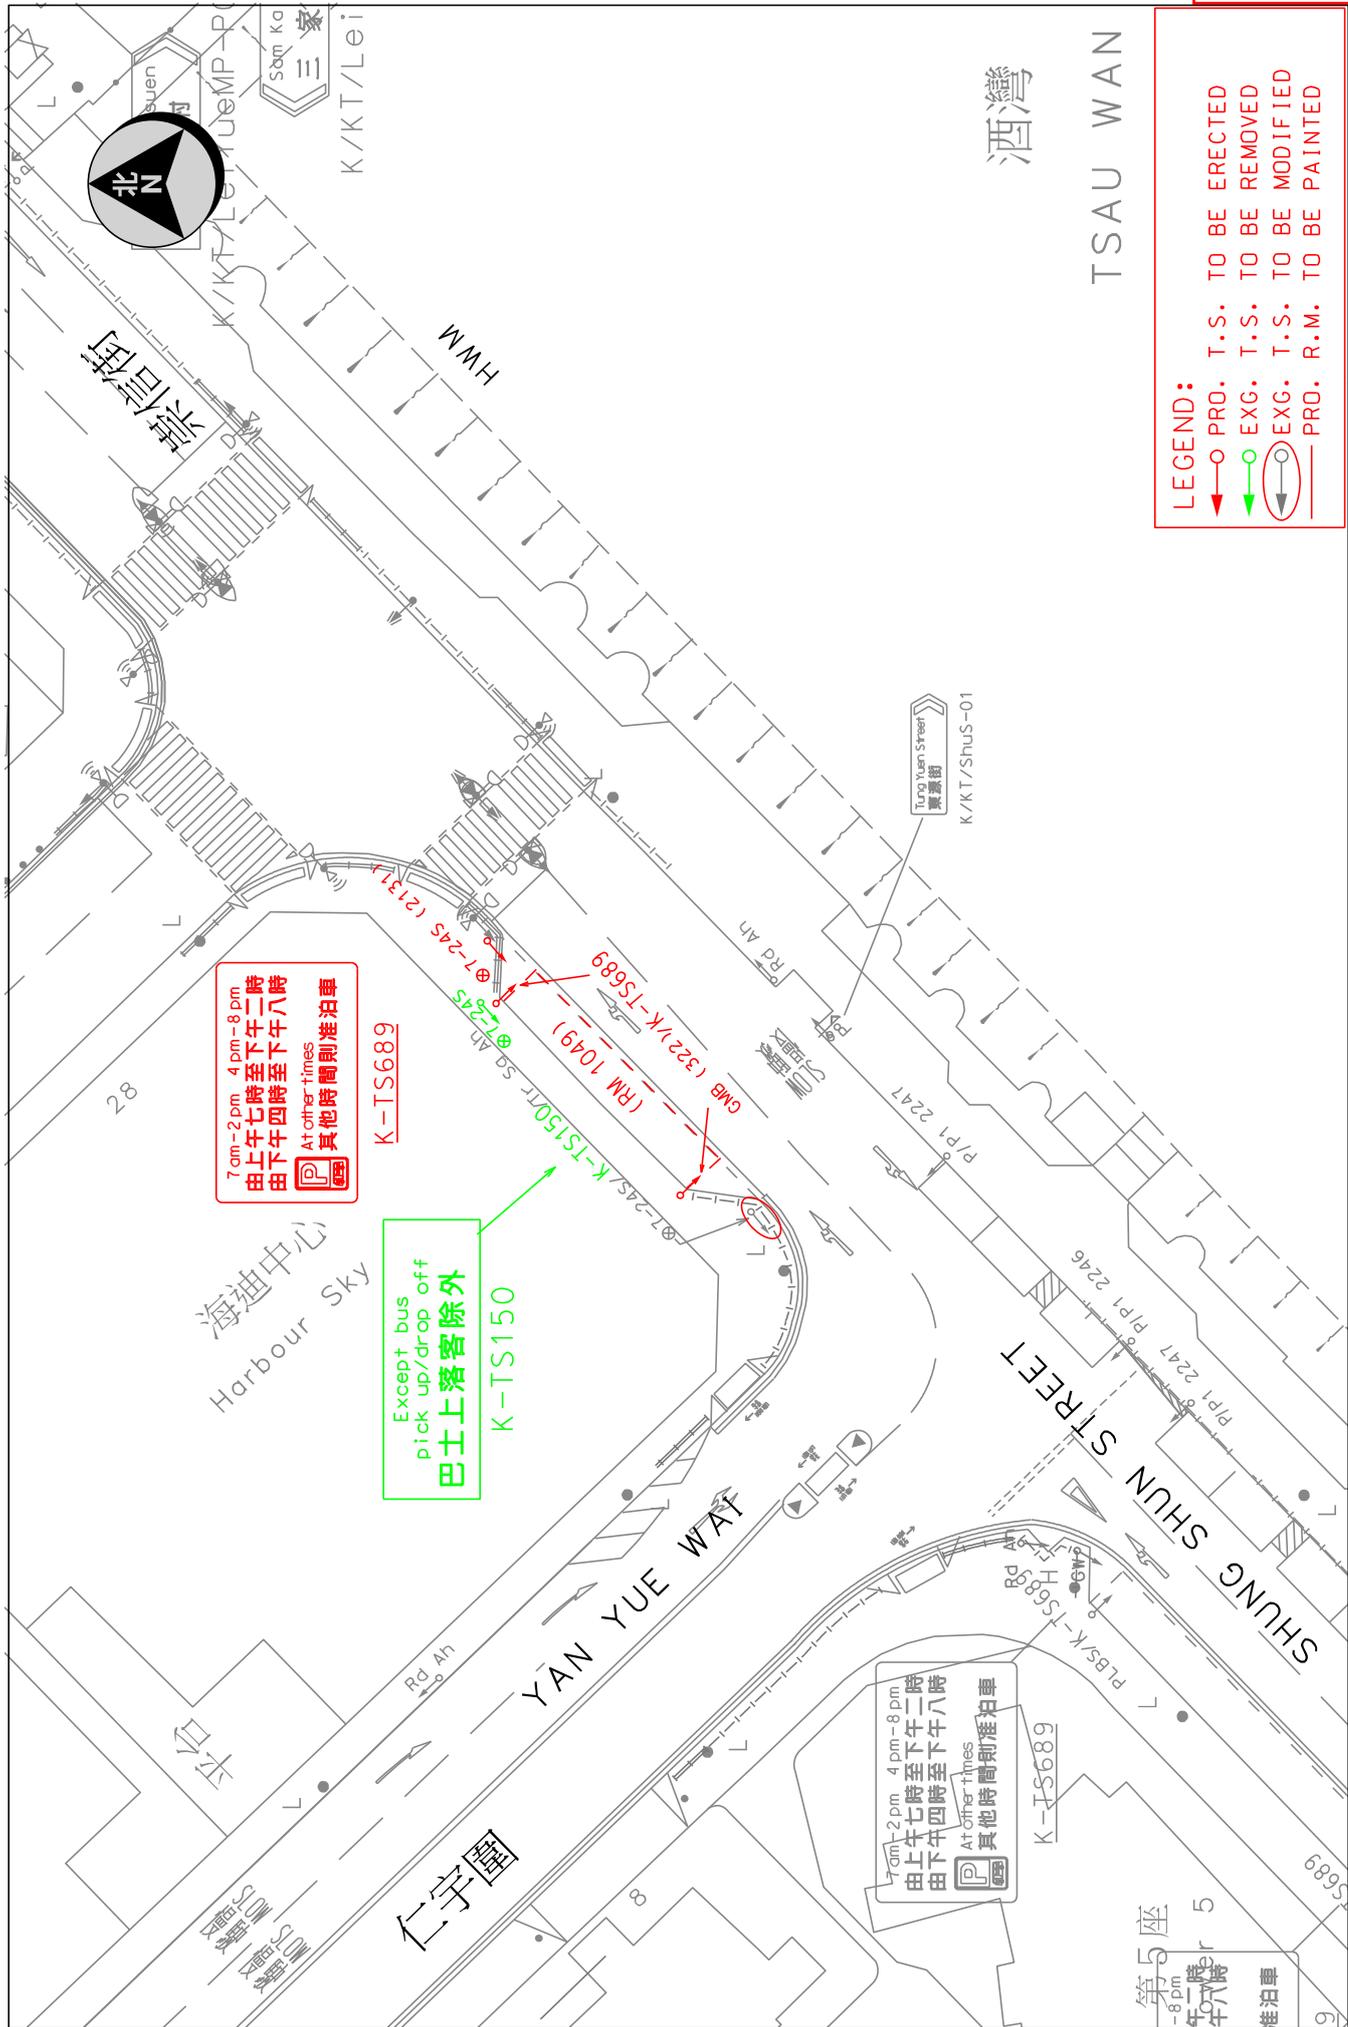


 運輸署 Transport Department	TRAFFIC ENGINEERING (KLN.) DIV.	Location Shung Shun Street near Yan Yue Wai	WR/CS/TE/KL/25/00393	WRF NO. WR/HY/TE/KL/25/01802
	Survey Sheet No. : K11S04C	Scale: 1:500 (A4)	Drawing No. : K251008.01	Date : 26-09-2025

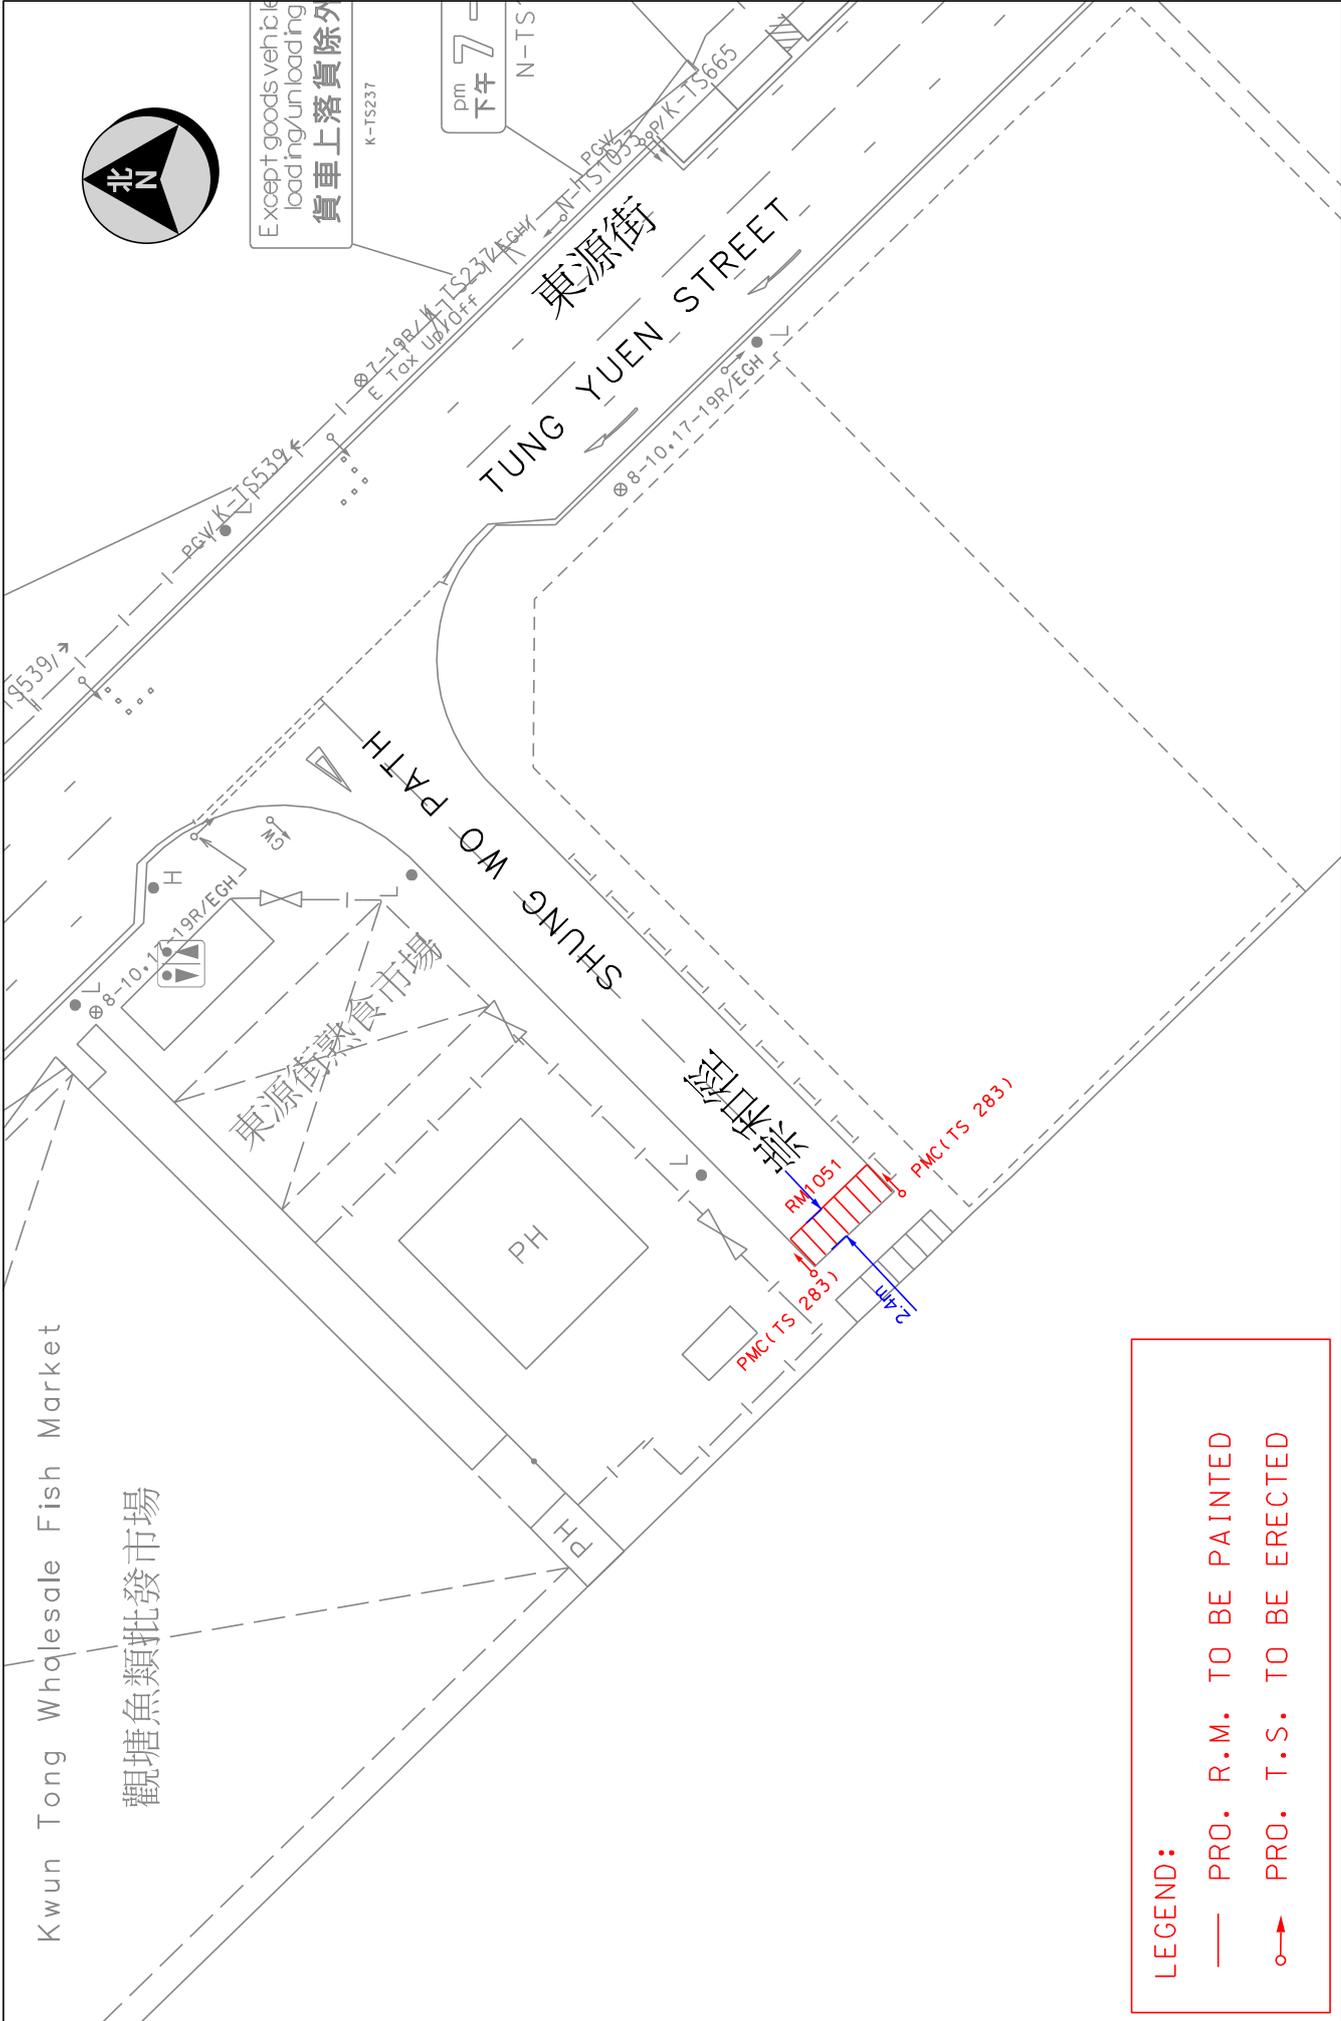


LEGEND:


- PRO. R.M. TO BE PAINTED
- PRO. T.S. TO BE ERECTED

 運輸署 Transport Department	TRAFFIC ENGINEERING (KLN.) DIV.	Location : Shung Wo Path near Tung Yuen Street Survey Sheet No. : K11S04C	Scale: 1:500 (A4) Drawing No. : K251038.01	WRF NO. WR/HY/TE/KL/25/01804 Date : 06-10-2025
--	------------------------------------	--	---	---

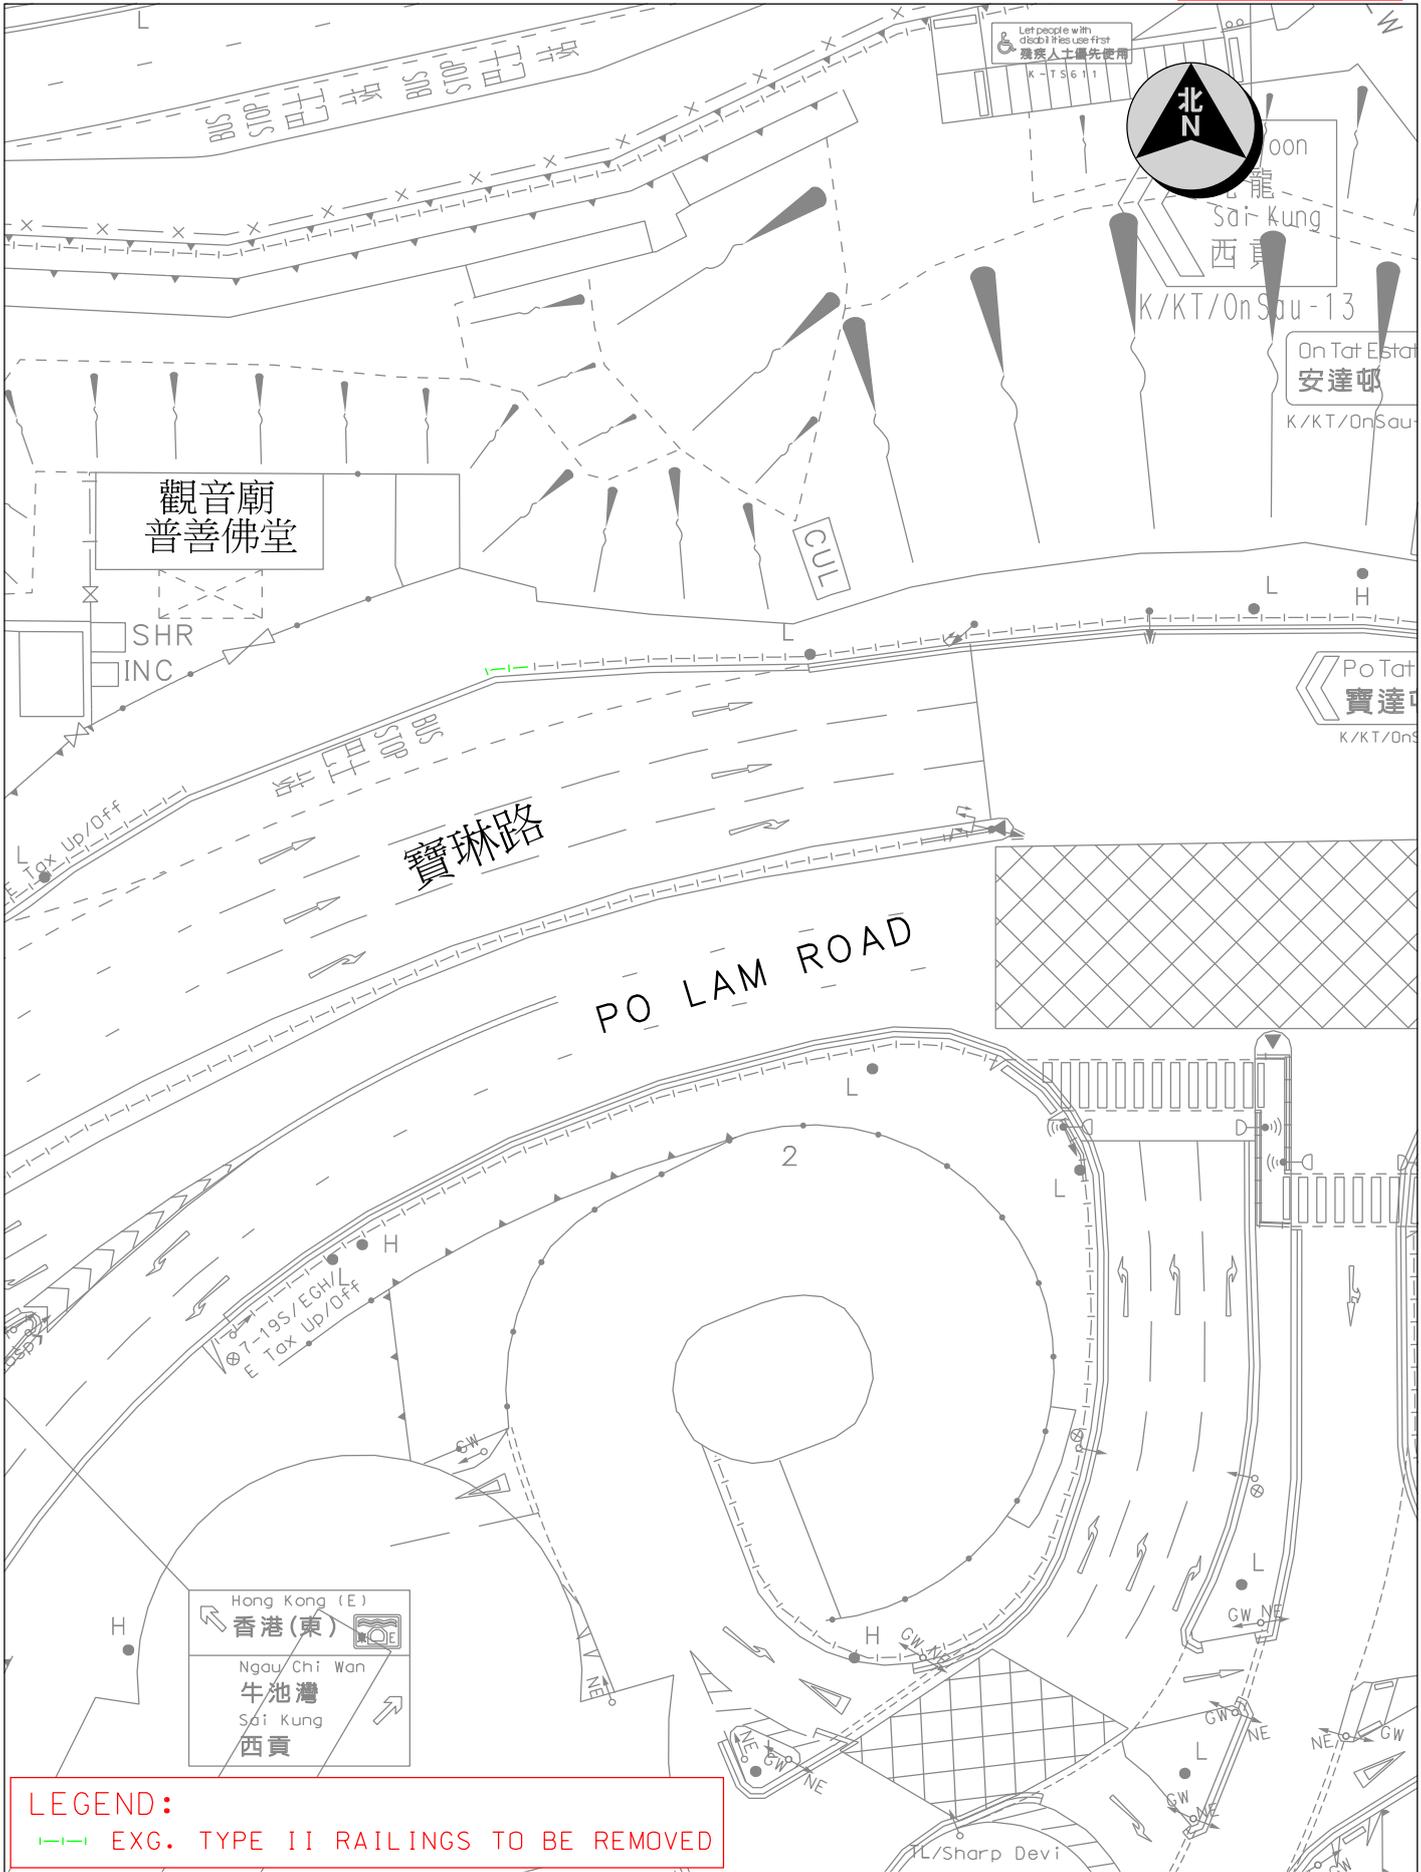

Location : Po Lam Road near Kwun Yam Temple		Survey Sheet No. K11Q19A	Scale 1 : 500 (A4)
 運輸署 Transport Department	TRAFFIC ENGINEERING (KLN.) DIV.	WRF NO. WR/HY/TE/KL/25/01583	Drawing No. K250789.01
			Date 21-07-2025

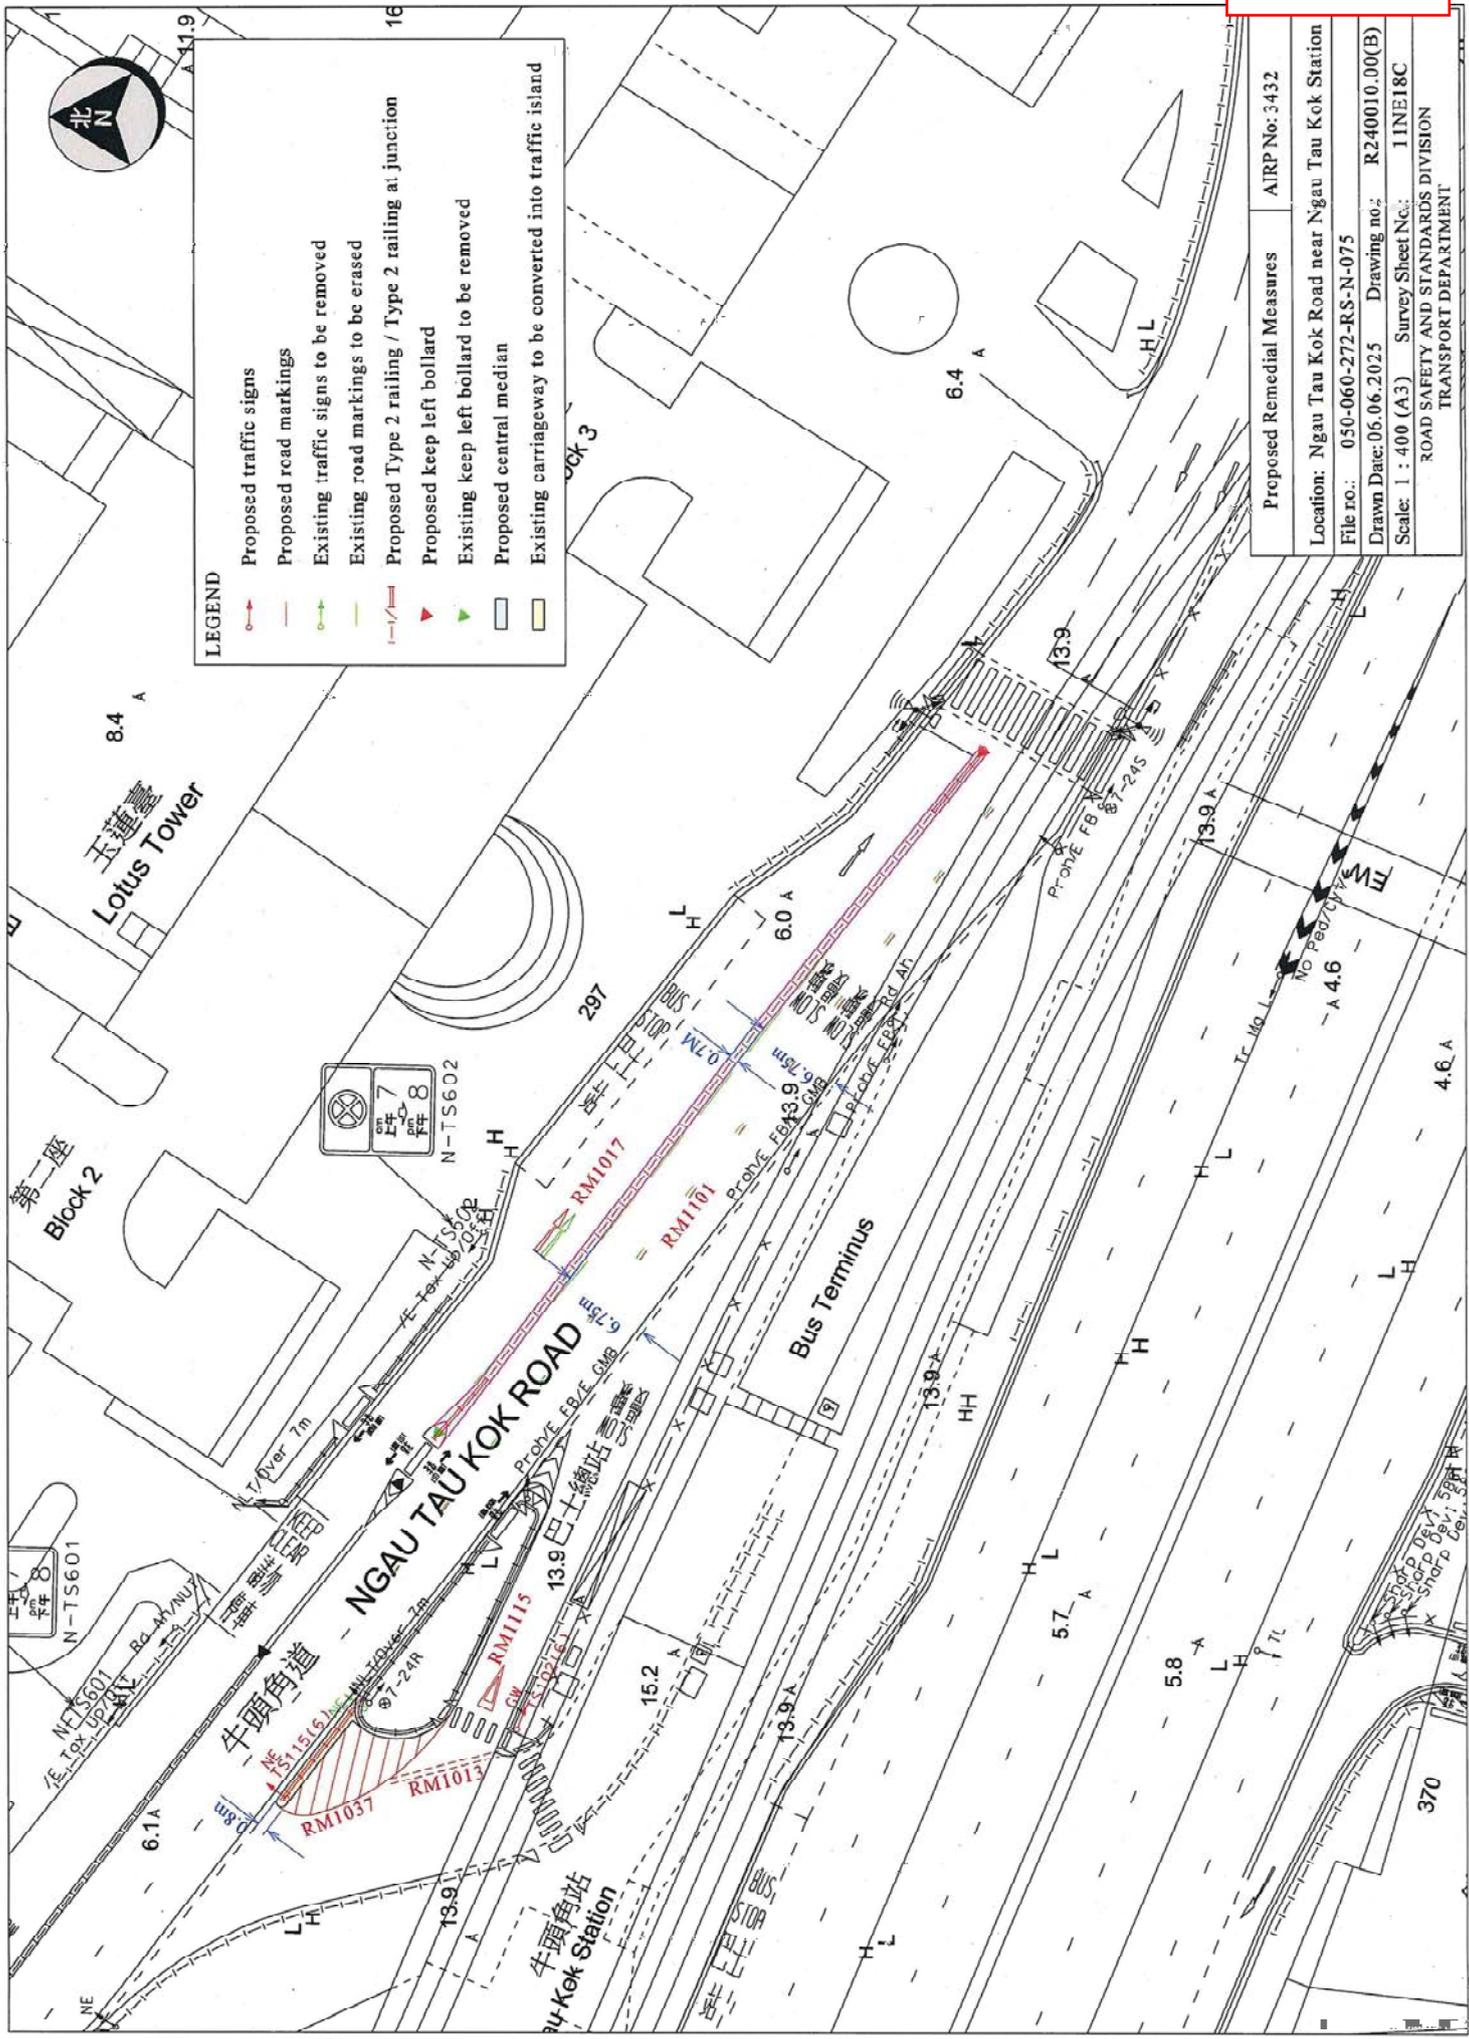

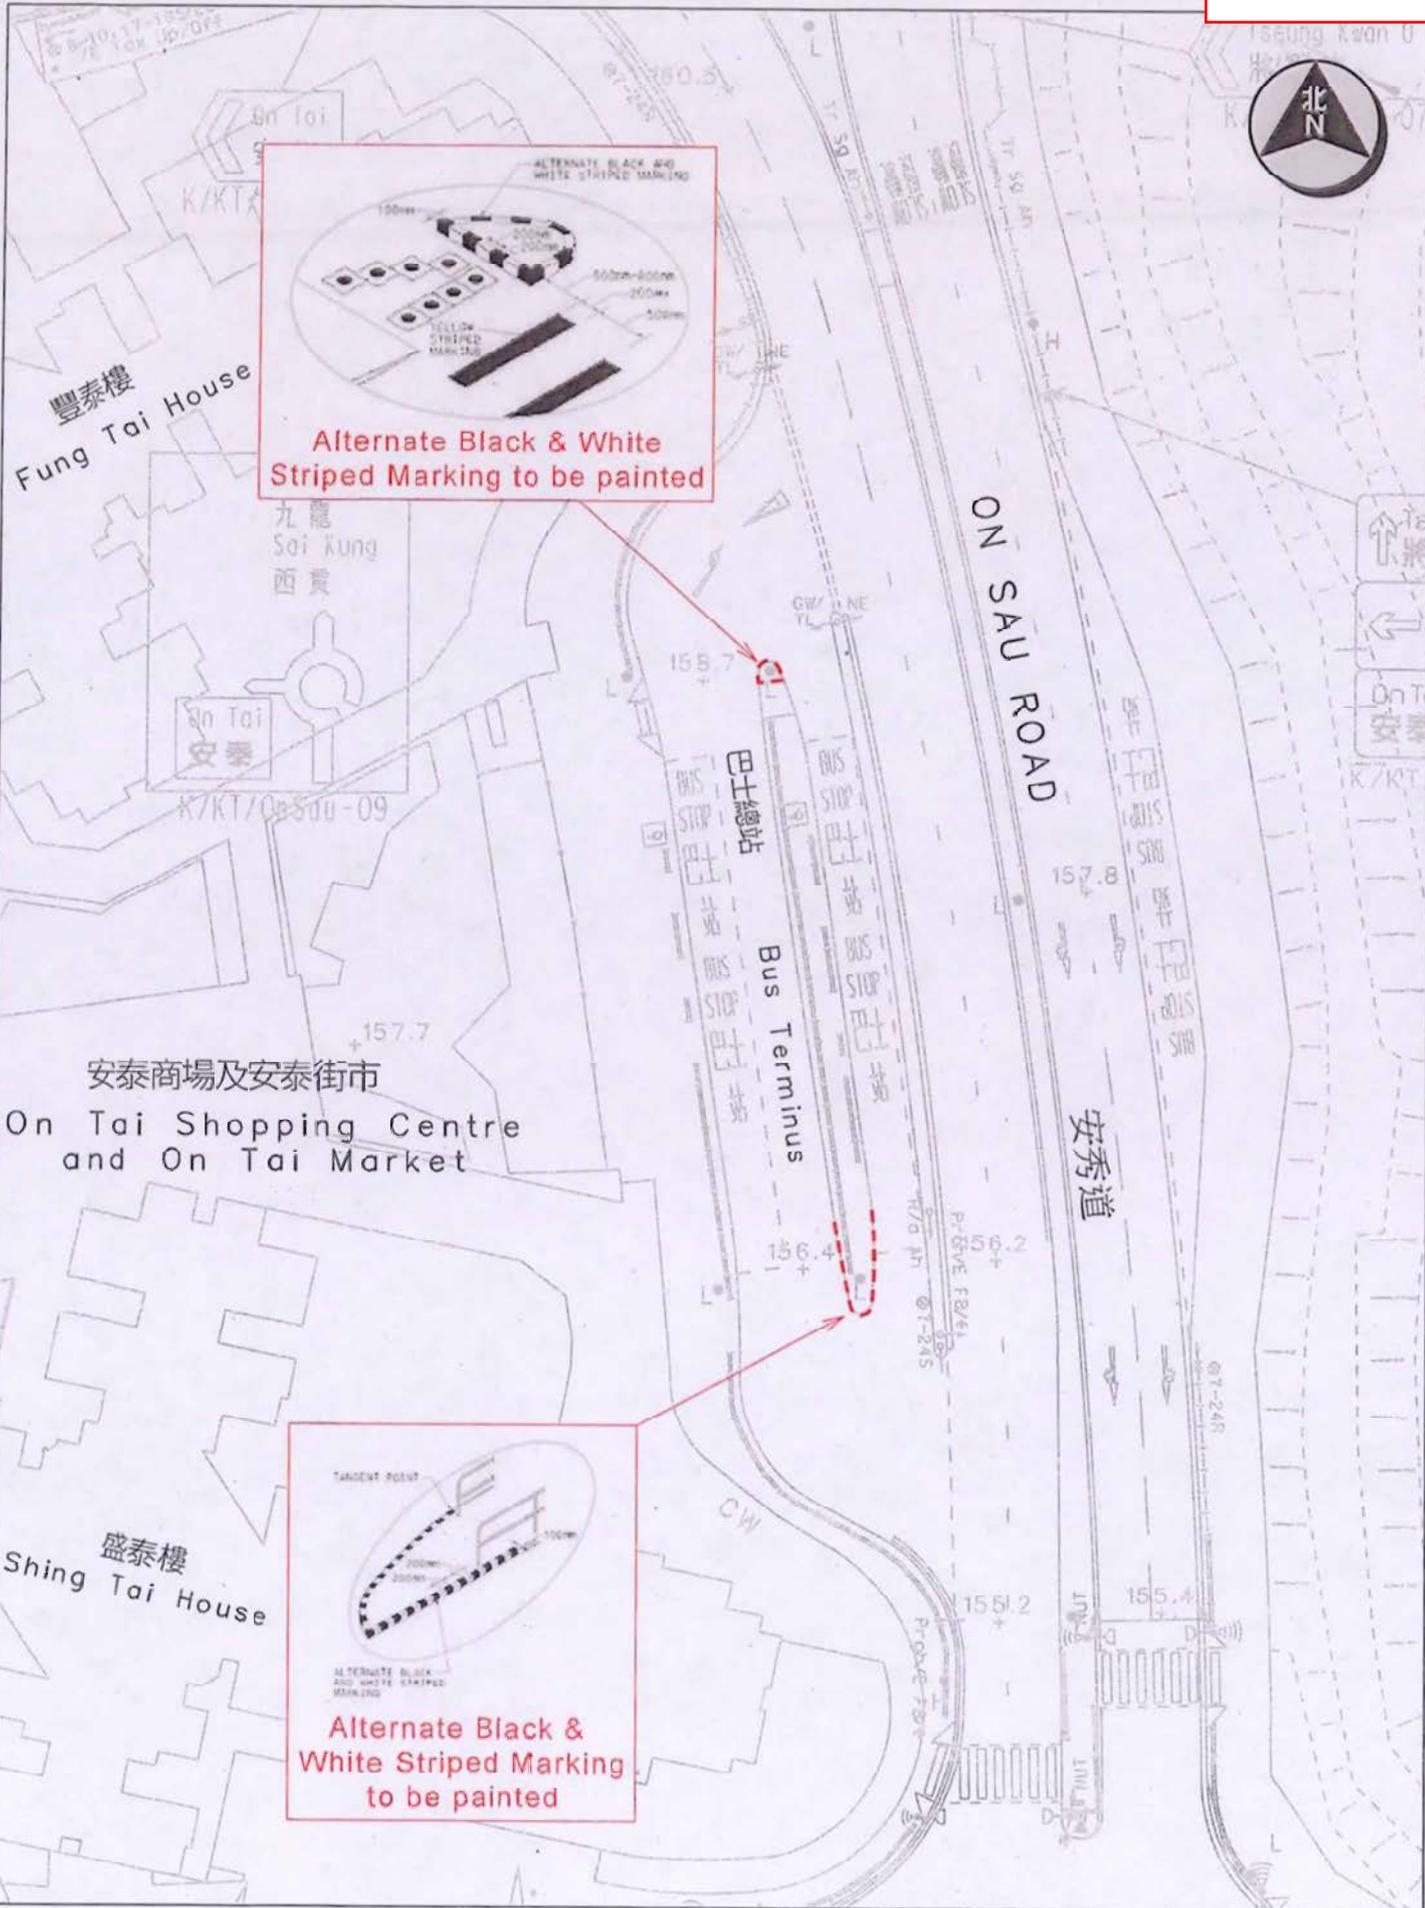

Location : On Sau Road On Tai Bus Terminus

Survey Sheet No.:
K11Q13D

Scale:
1:500 (A4)




TRAFFIC ENGINEERING
(KLN.) DIV.

WRF NO.
WR/HY/TE/KL/26/00124


Drawing No.:
K260009.01

Date:
6 January 2026

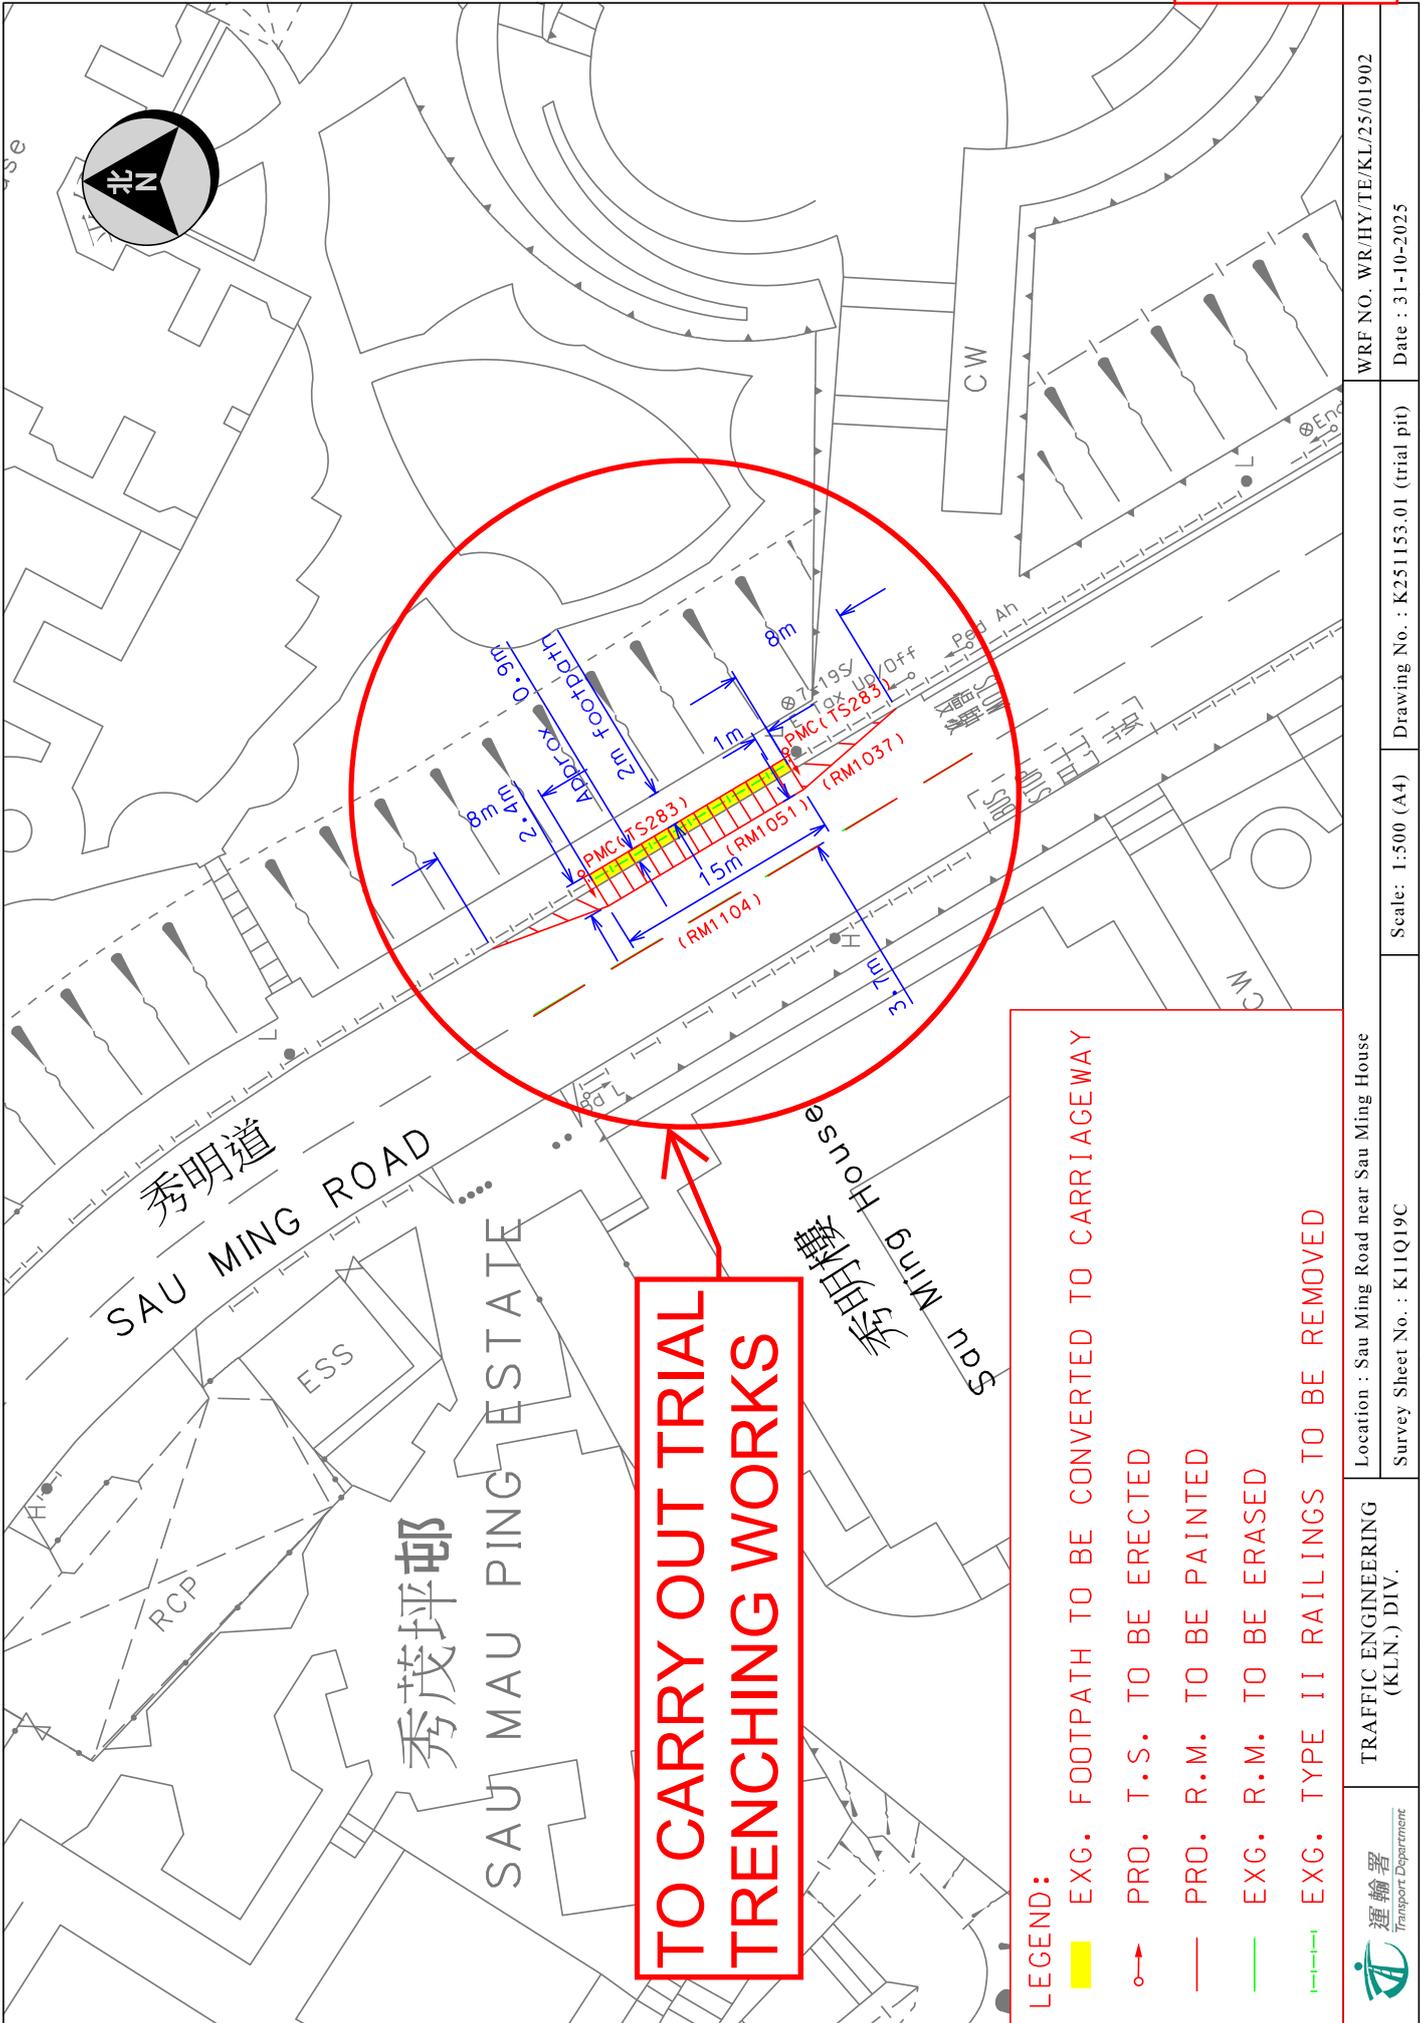


**TO CARRY OUT TRIAL
TRENCHING WORKS**

- LEGEND:**
- EXG. FOOTPATH TO BE CONVERTED TO CARRIAGEWAY
 - PRO. T.S. TO BE ERECTED
 - PRO. R.M. TO BE PAINTED
 - EXG. R.M. TO BE ERASED
 - EXG. TYPE II RAILINGS TO BE REMOVED

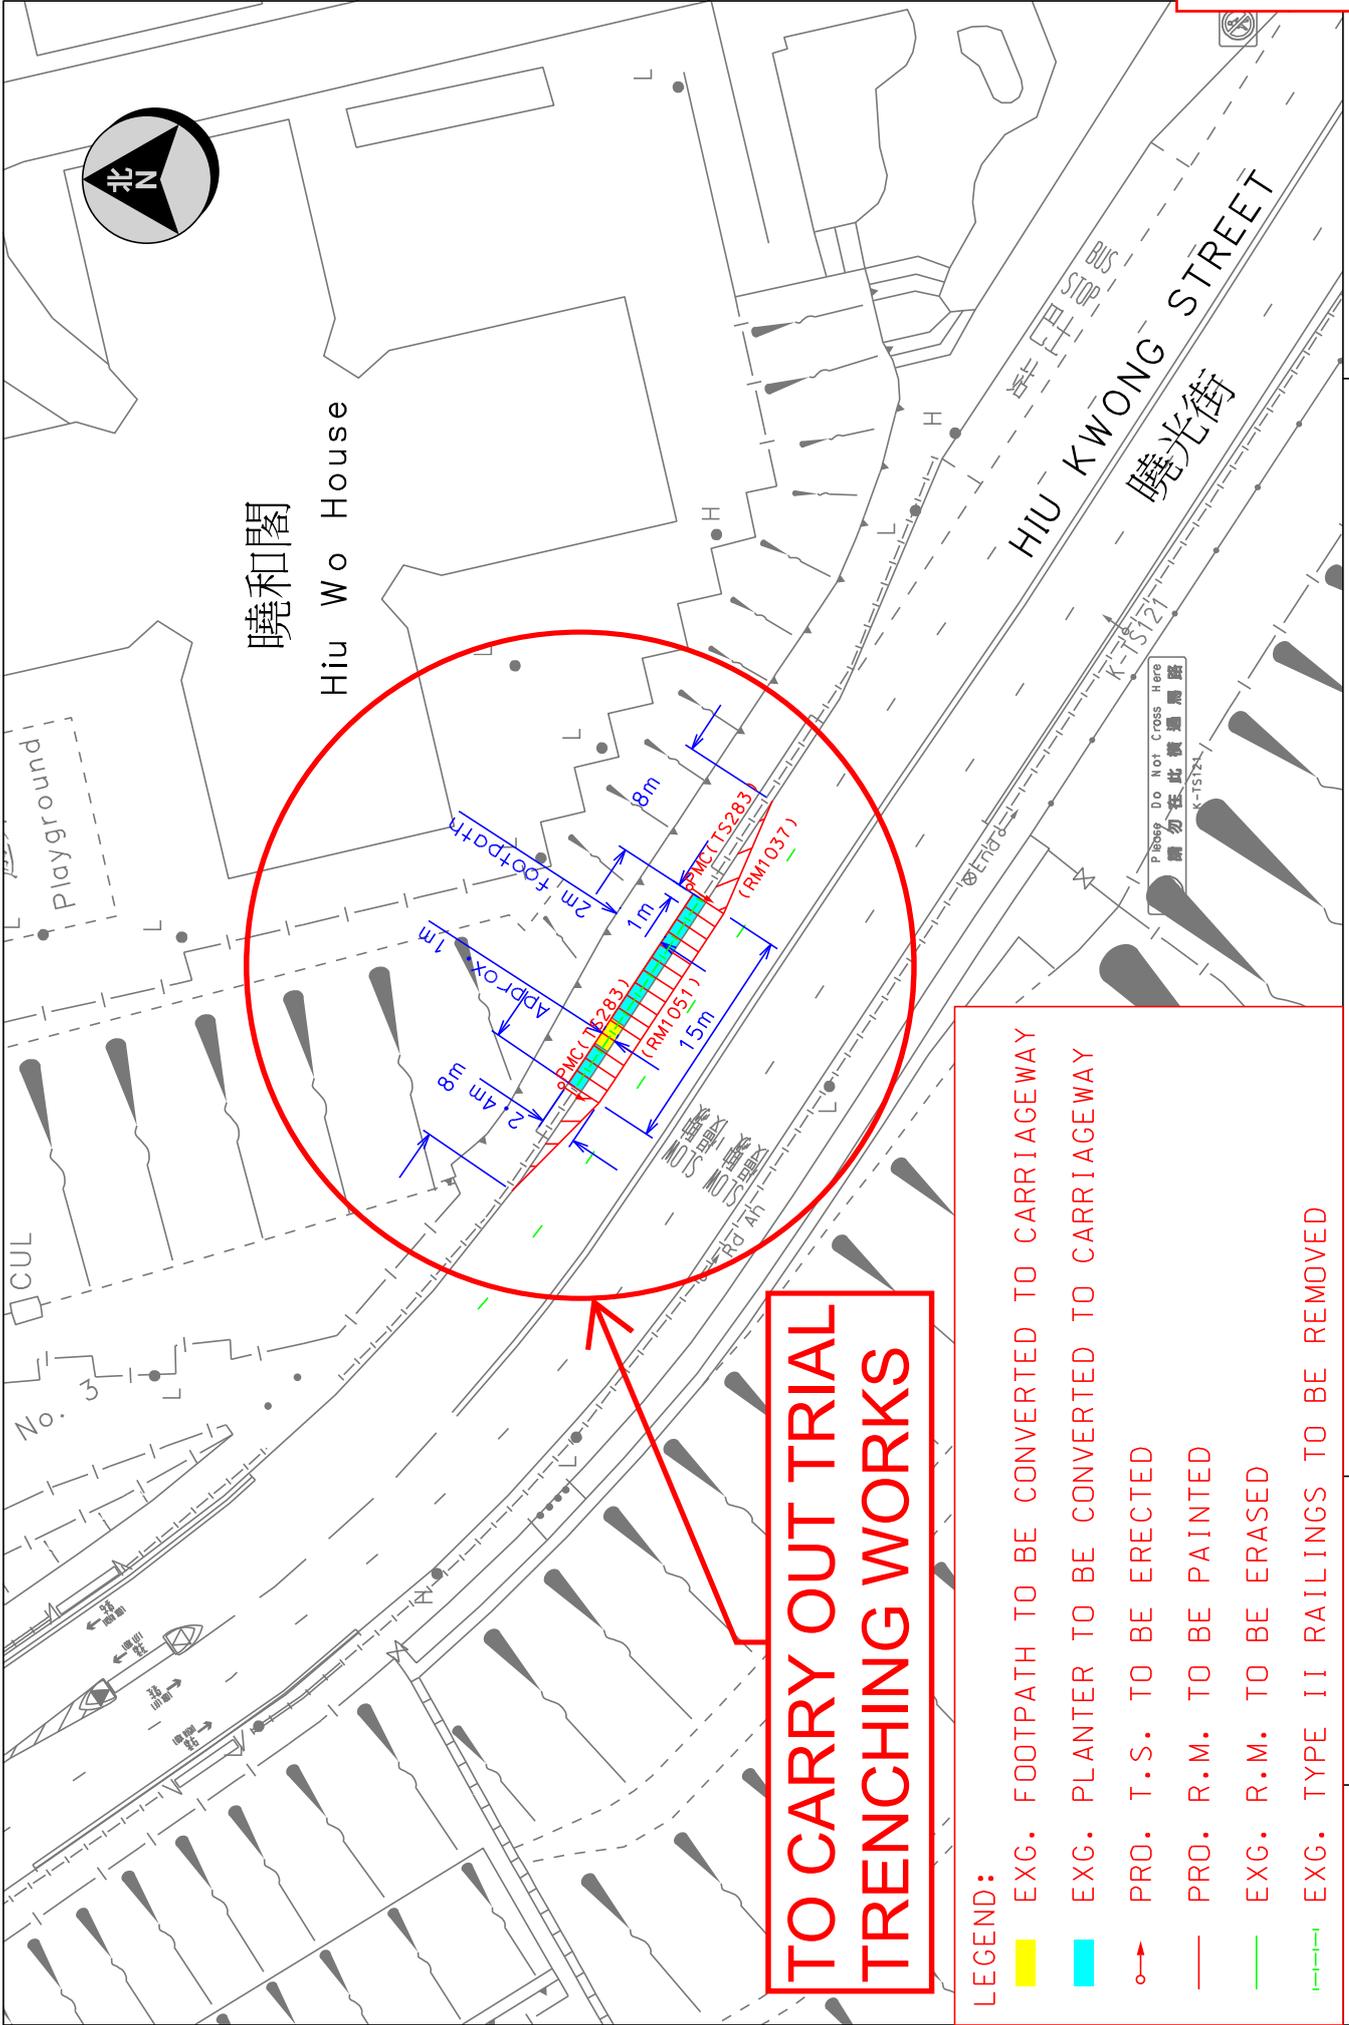

TO CARRY OUT TRIAL TRENCHING WORKS

- LEGEND:**
- █ EXG. FOOTPATH TO BE CONVERTED TO CARRIAGEWAY
 - █ EXG. PLANTER TO BE CONVERTED TO CARRIAGEWAY
 - PRO. T.S. TO BE ERECTED
 - PRO. R.M. TO BE PAINTED
 - EXG. R.M. TO BE ERASED
 - - - EXG. TYPE II RAILINGS TO BE REMOVED

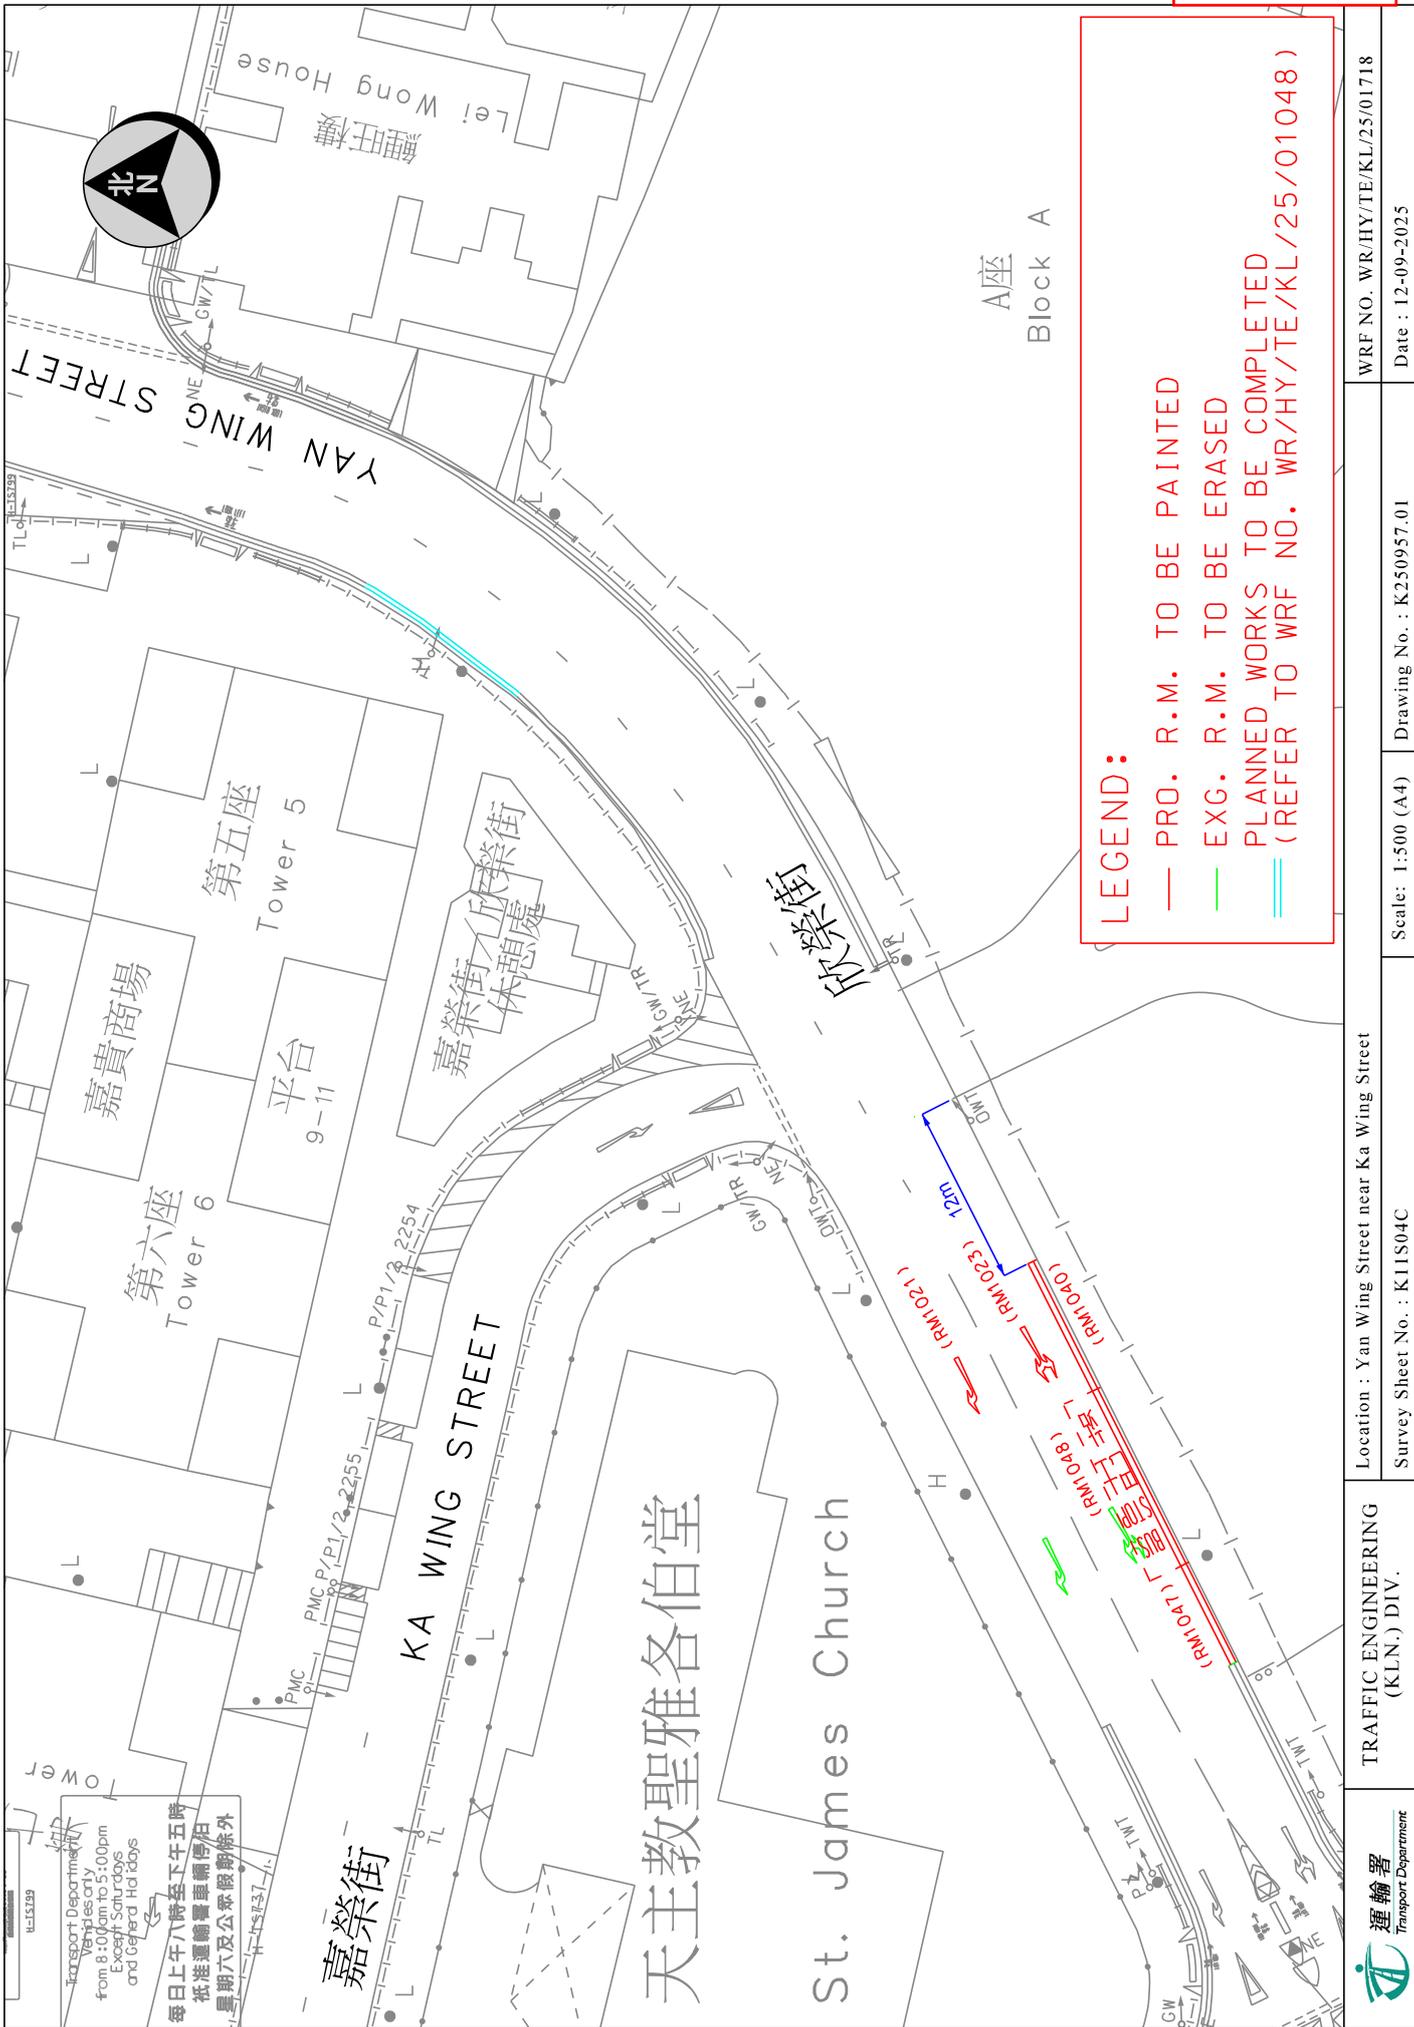

LEGEND:

- PRO. R.M. TO BE PAINTED
- EXG. R.M. TO BE ERASED
- PLANNED WORKS TO BE COMPLETED (REFER TO WRF NO. WR/HY/TE/KL/25/01048)


 <p>運輸署 Transport Department</p>	<p>TRAFFIC ENGINEERING (KLN.) DIV.</p>	<p>Location : Yan Wing Street near Ka Wing Street Survey Sheet No. : K11S04C</p>	<p>Scale: 1:500 (A4) Drawing No. : K250957.01</p>	<p>WRF NO. WR/HY/TE/KL/25/01718 Date : 12-09-2025</p>
---	--	--	---	---

Transport Department
Vehicle only
from 8:00am to 5:00pm
Except Saturdays
and General Holidays


每日上午八時至下午五時
祇准運輸車輛通行
星期六及公眾假期除外




A座
Block A

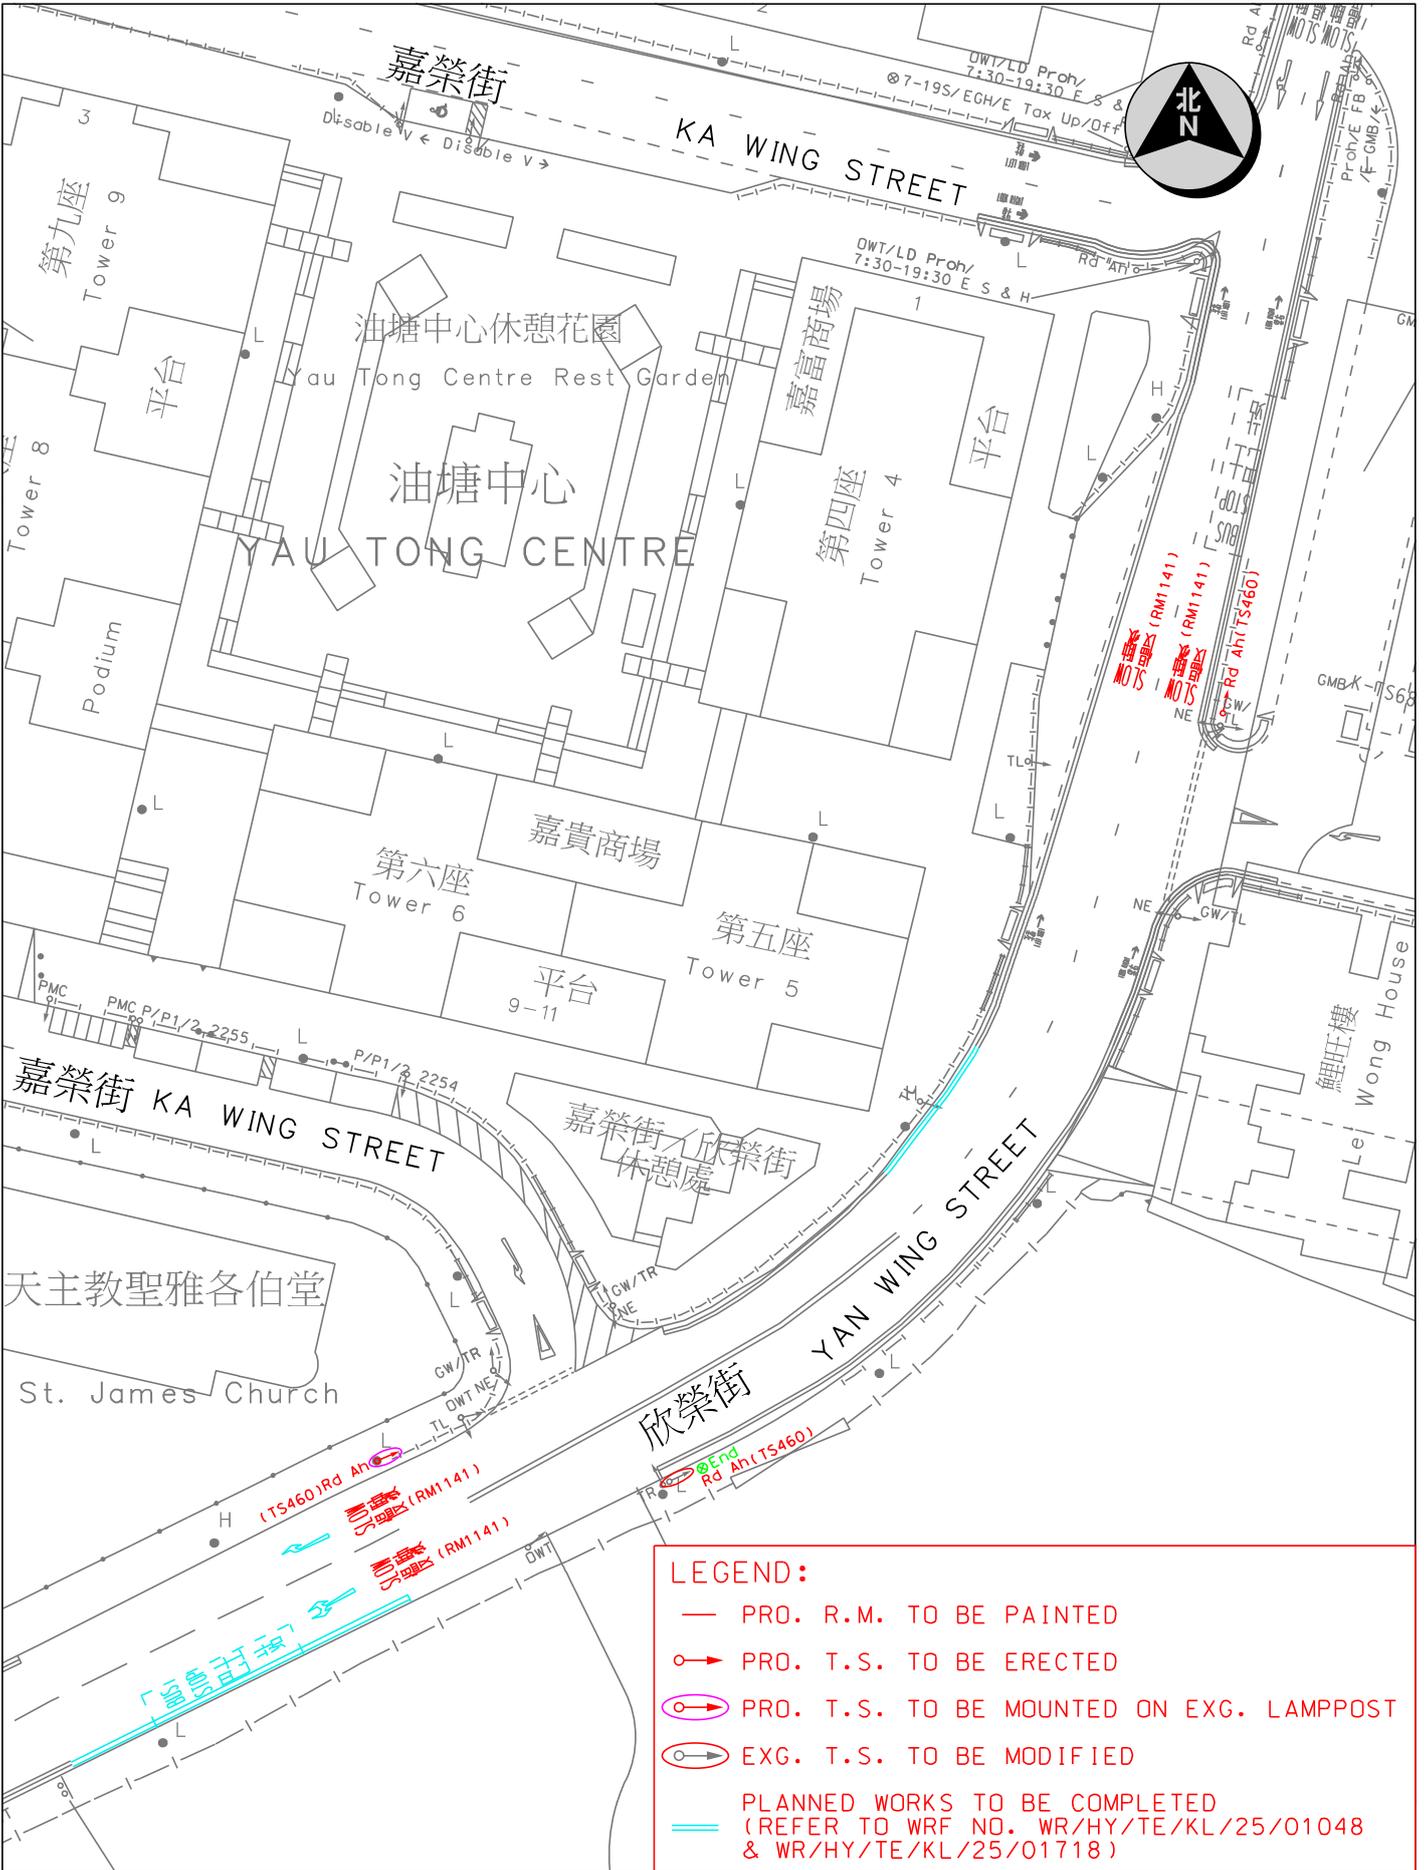

Location : Yan Wing Street near Ka Wing Street		Survey Sheet No. K11S04C	Scale 1 : 600 (A4)
 <p>運輸署 Transport Department</p>	TRAFFIC ENGINEERING (KLN.) DIV.	WRF NO. WR/HY/TE/KL/26/00077	Drawing No. K251174.01
			Date 5-11-2025

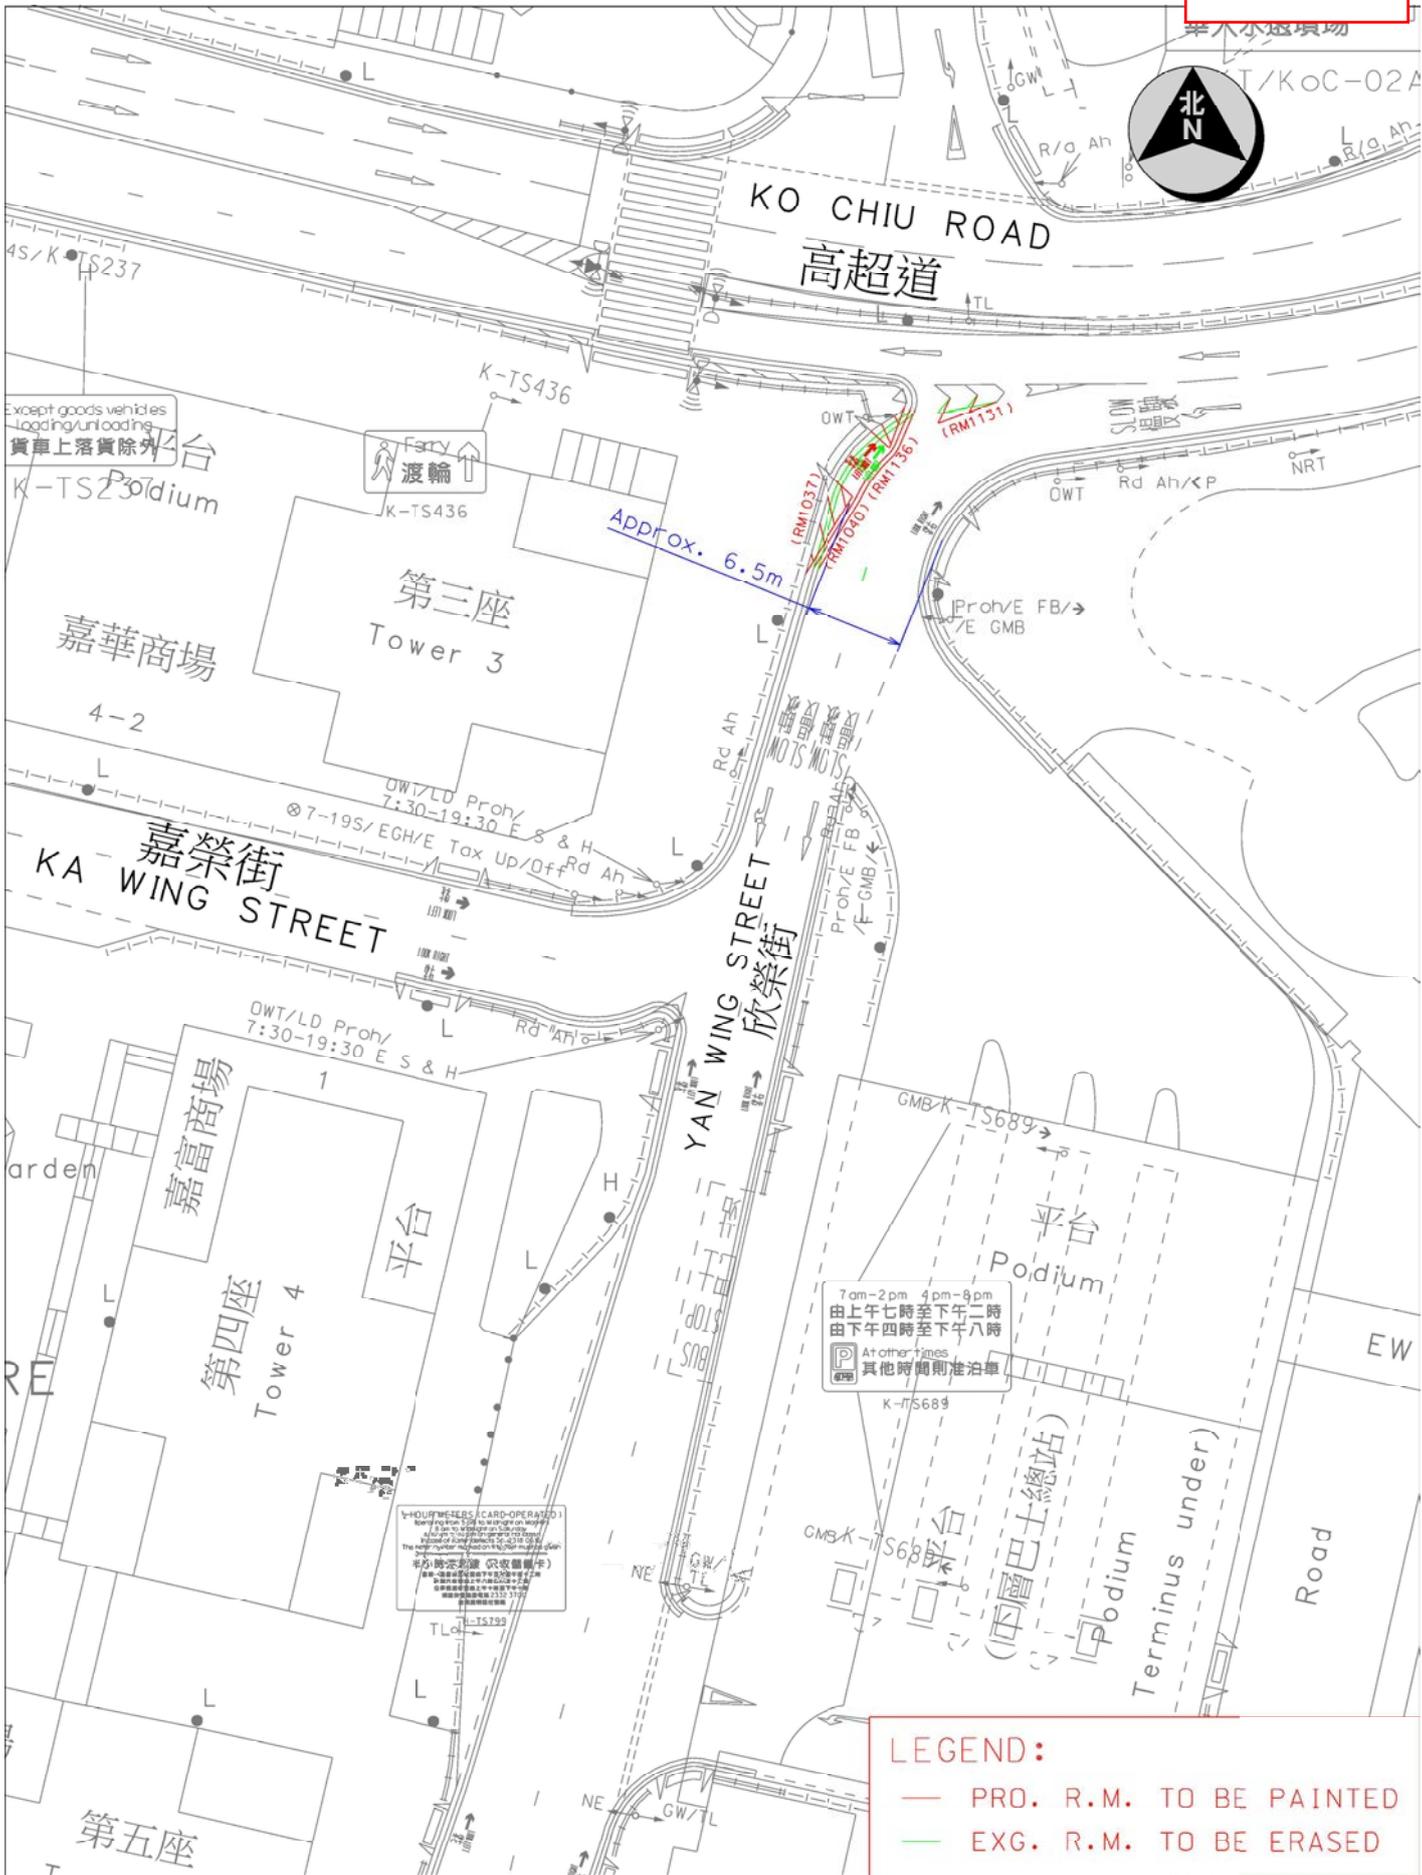

Location : Yan Wing Street near Ko Chiu Road		Survey Sheet No. K11S04C	Scale 1 : 500 (A4)
<p>運輸署 Transport Department</p>	TRAFFIC ENGINEERING (KLN.) DIV.	WRF NO. WR/HY/TE/KL/26/00243	Date 06-01-2026
		Drawing No. K251364.01	

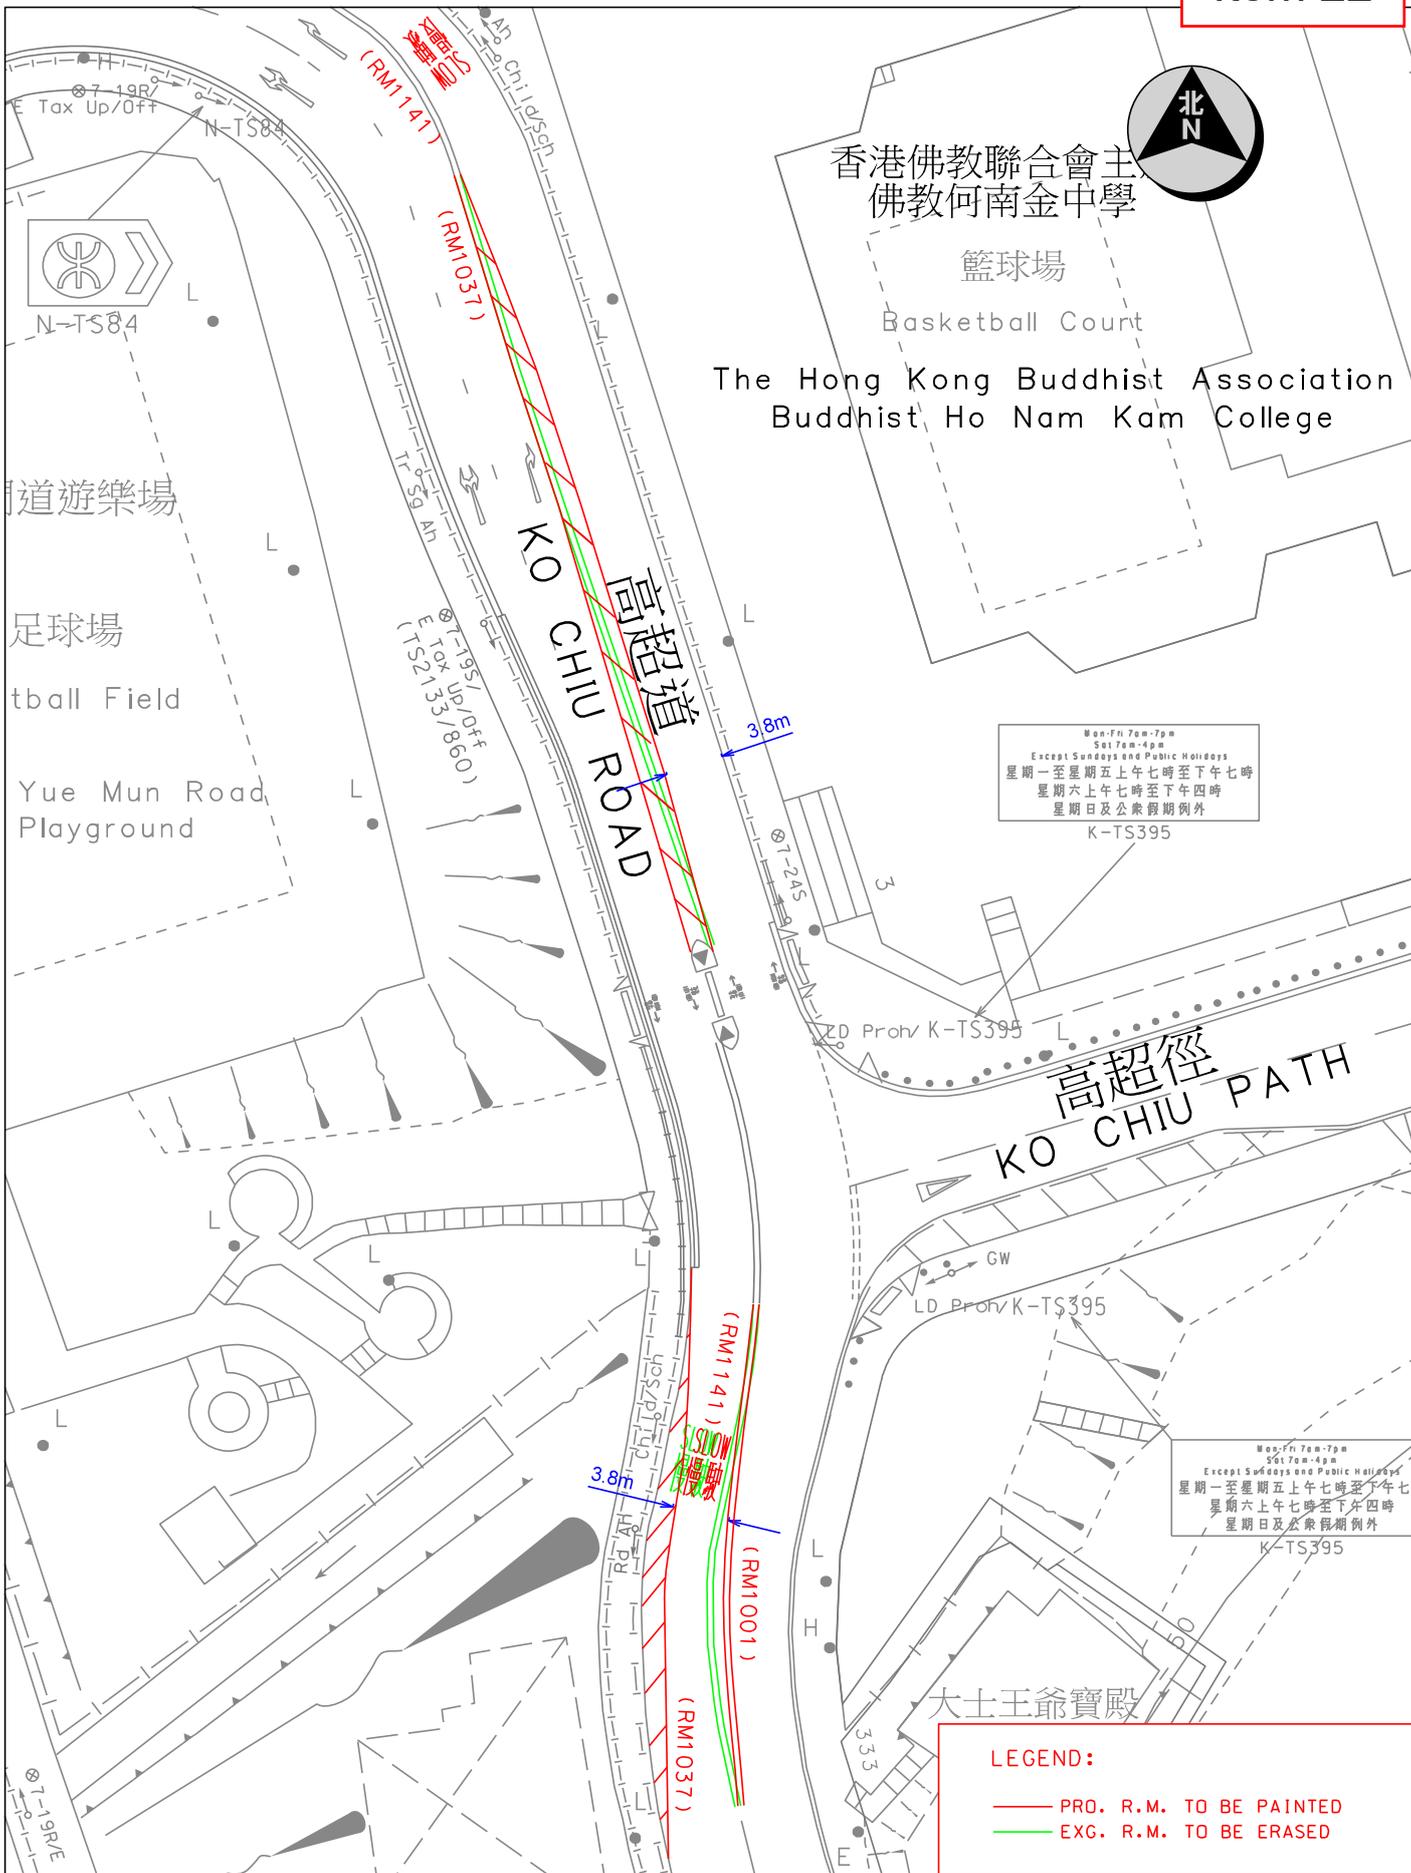


Mon-Fri 7am-7pm
Sat 7am-4pm
Except Sundays and Public Holidays
星期一至星期五上午七時至下午七時
星期六上午七時至下午四時
星期日及公眾假期例外
K-TS395

Mon-Fri 7am-7pm
Sat 7am-4pm
Except Sundays and Public Holidays
星期一至星期五上午七時至下午七時
星期六上午七時至下午四時
星期日及公眾假期例外
K-TS395


LEGEND:
 — PRO. R.M. TO BE PAINTED
 — EXG. R.M. TO BE ERASED

Location : Ko Chiu Road near Ko Chiu Path		Survey Sheet No. K11S04A	Scale 1 : 500 (A4)
 運輸署 Transport Department	TRAFFIC ENGINEERING (KLN.) DIV.	WRF NO. WR/HY/TE/KL/26/00067	Drawing No. K251002.01A
			Date 16-12-2025

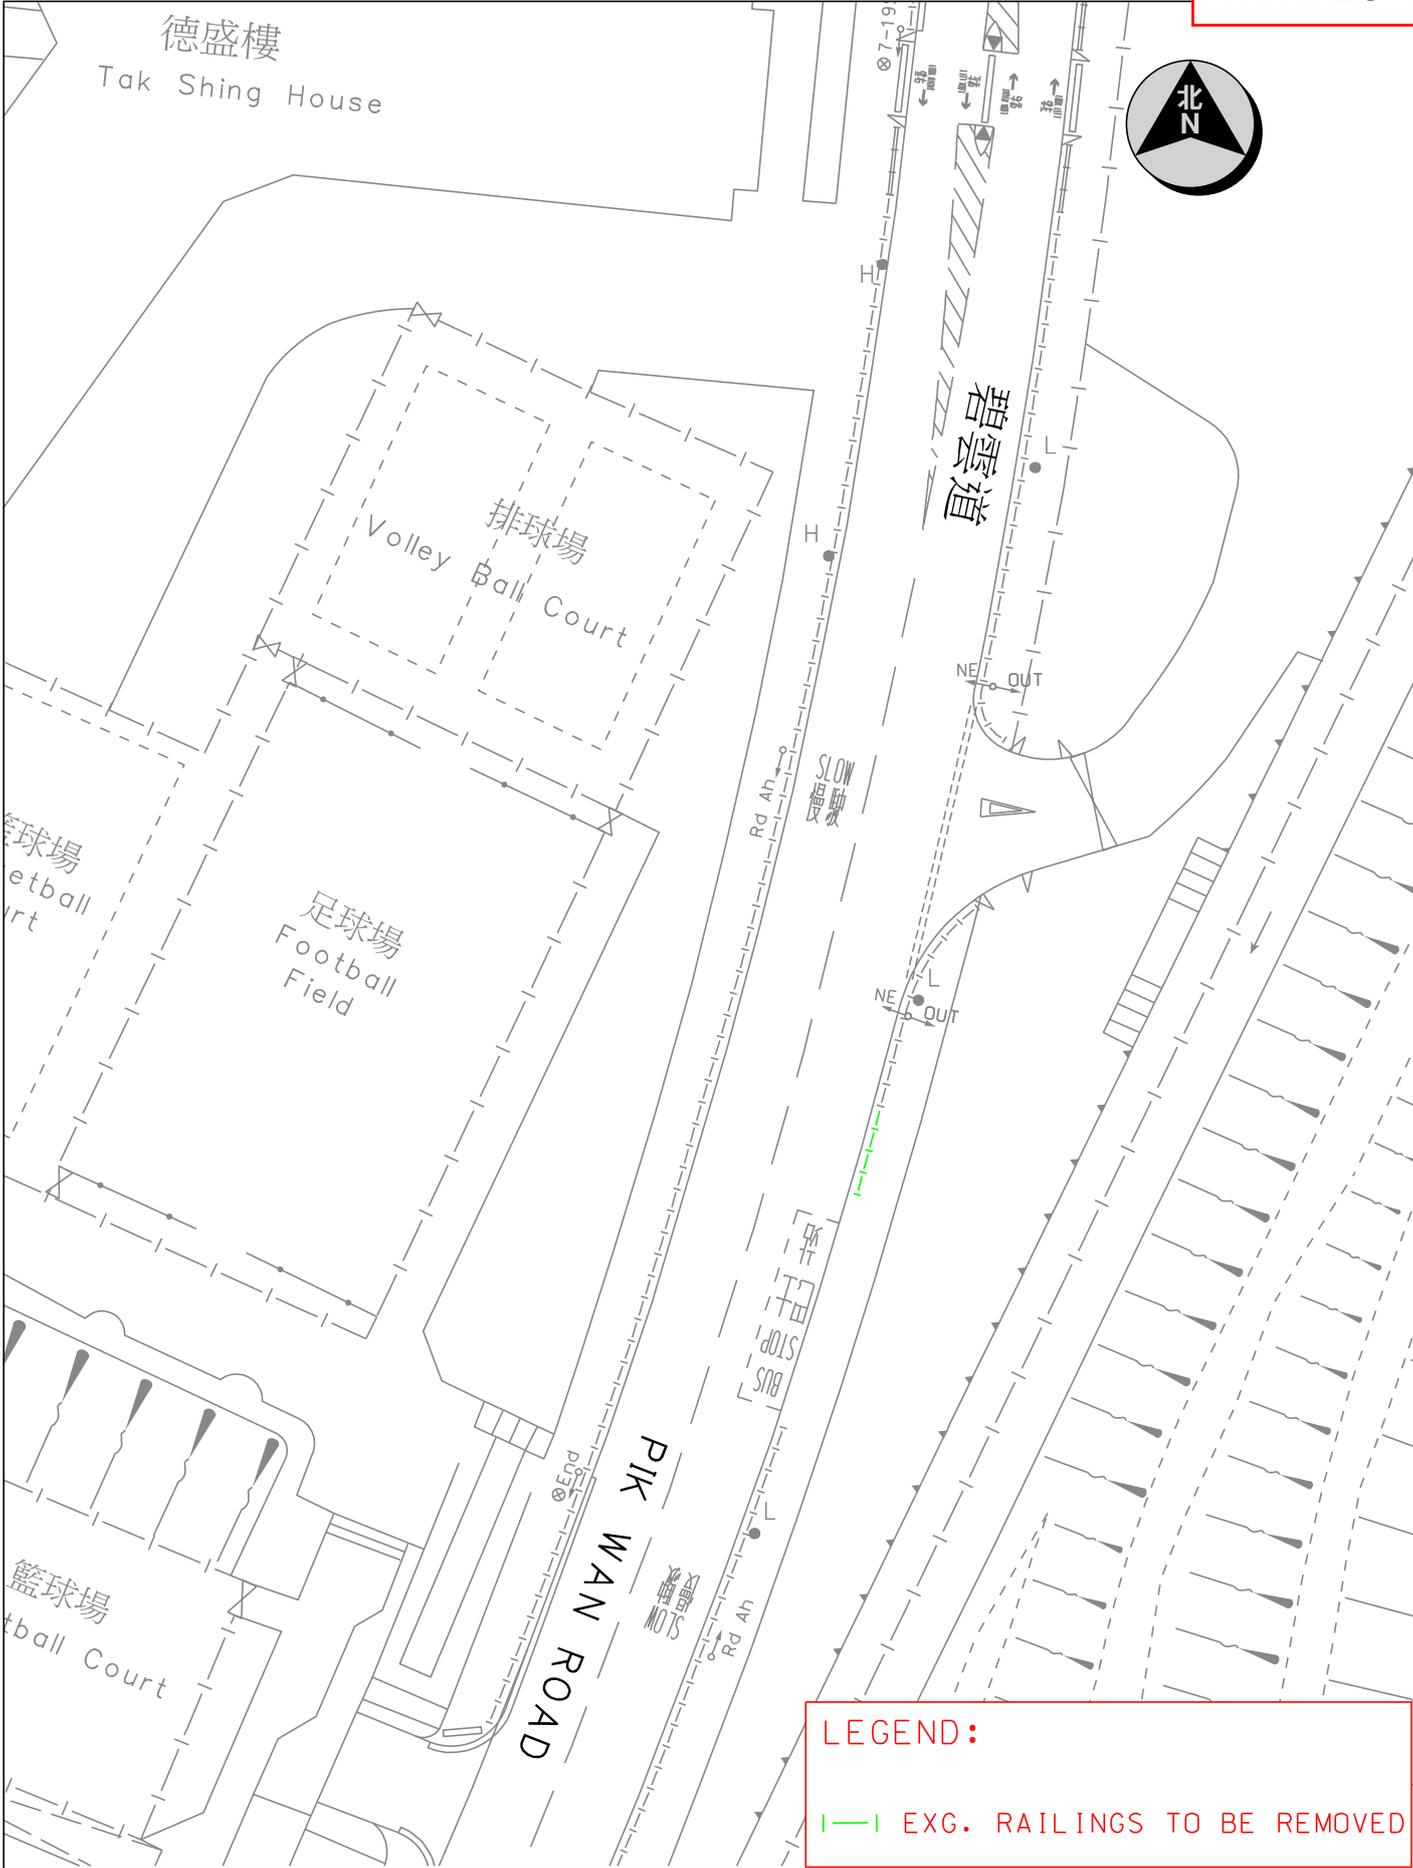

LEGEND:
 —| EXG. RAILINGS TO BE REMOVED

Location : Pik Wan Road near Tak Lung House		Survey Sheet No. K11Q24A	Scale 1 : 500 (A4)
 運輸署 Transport Department	TRAFFIC ENGINEERING (KLN.) DIV.	WRF NO. WR/HY/TE/KL/26/00080	Drawing No. K251340.01
			Date 12-12-2025

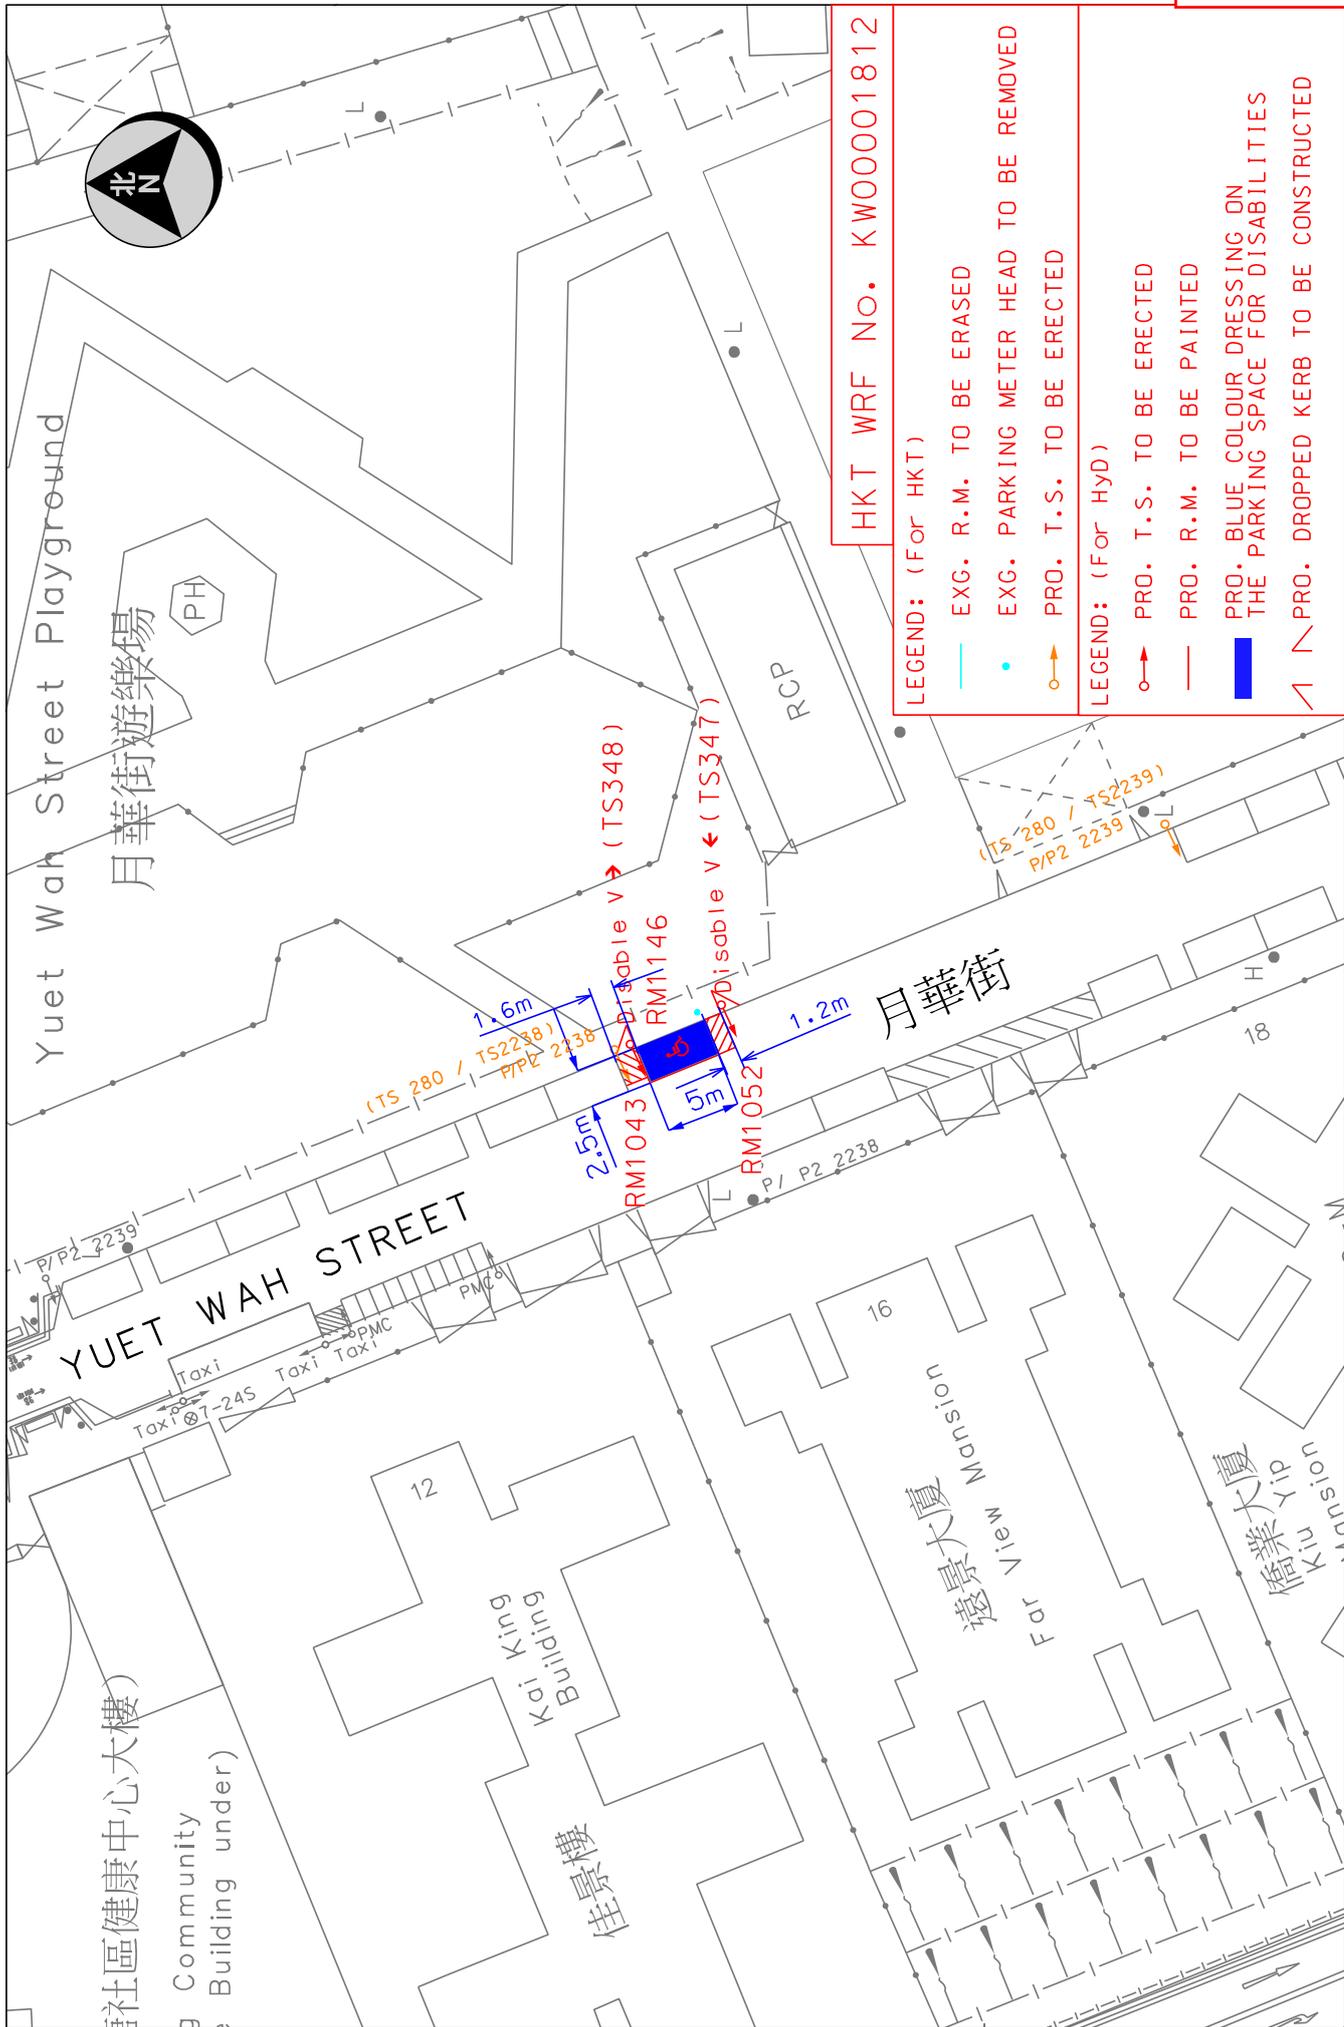

HKT WRF No. KW00001812

- LEGEND: (For HKT)
- EXG. R.M. TO BE ERASED
 - EXG. PARKING METER HEAD TO BE REMOVED
 - PRO. T.S. TO BE ERECTED
- LEGEND: (For Hyd)
- PRO. T.S. TO BE ERECTED
 - PRO. R.M. TO BE PAINTED
 - PRO. BLUE COLOUR DRESSING ON THE PARKING SPACE FOR DISABILITIES
 - ∟ PRO. DROPPED KERB TO BE CONSTRUCTED

 <p>運輸署 Transport Department</p>	<p>TRAFFIC ENGINEERING (KLN.) DIV.</p>	<p>Location : Yuet Wah Street near Kai King Building Survey Sheet No. : K11Q18D</p>	<p>Scale: 1:500 (A4) Drawing No. : K250293.01</p>	<p>WRF NO. WR/HY/TE/KL/25/01192 Date : 25-03-2025</p>
	<p>Item 25</p>			

